



1 2 3 4 5 6

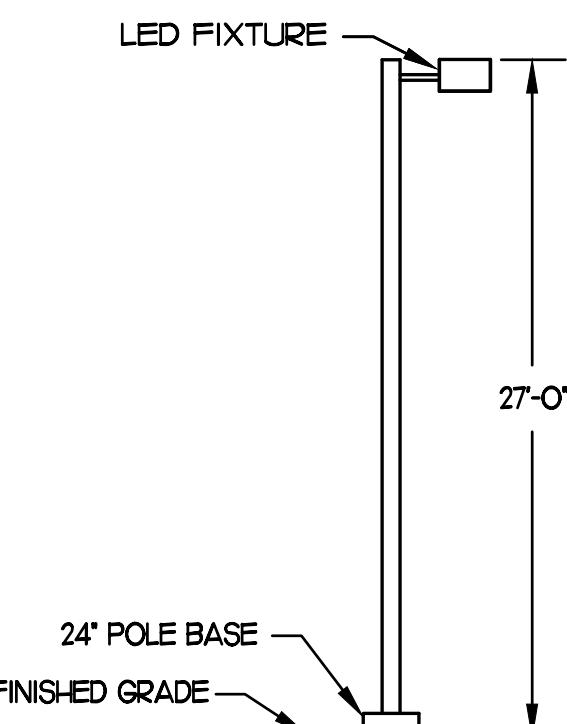

DI SITE LIGHTING POLE DETAIL

NOT TO SCALE

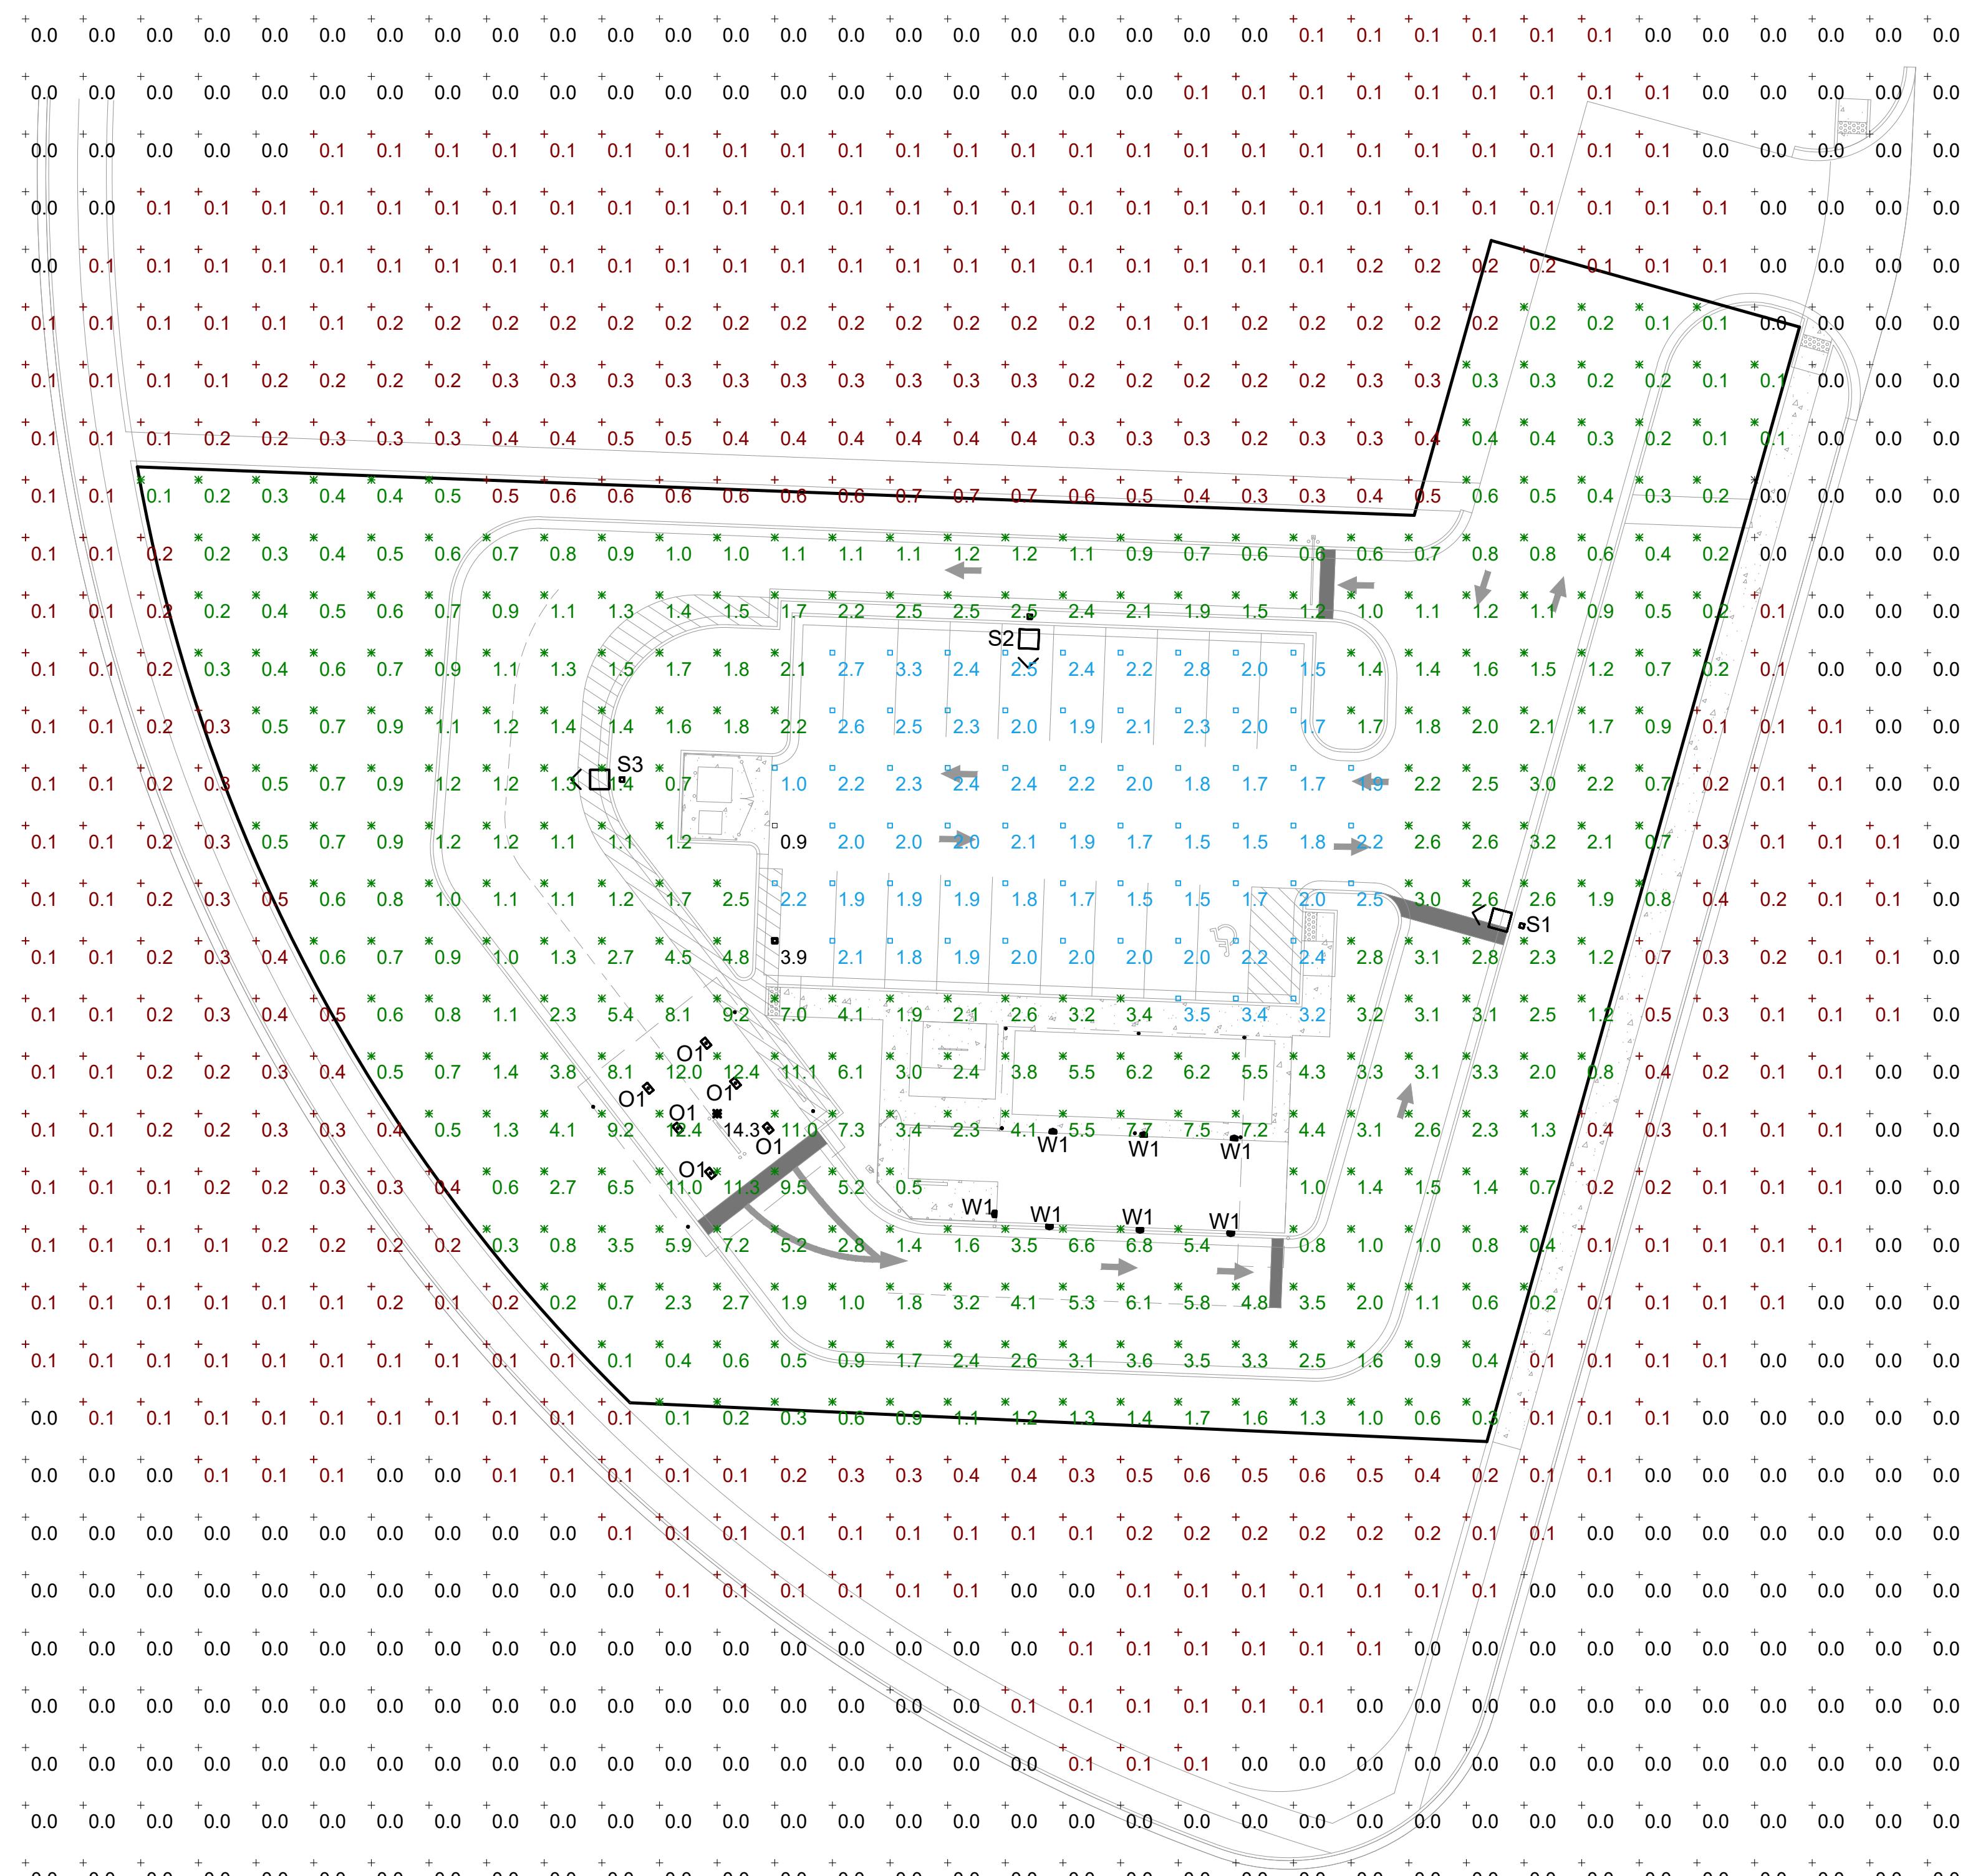


Schedule						
Symbol	Label	Quantity	Manufacturer	Catalog Number	Number Lamps	Lumens Per Lamp
□	S1	1	EATON - LUMARK (FORMER COOPER LIGHTING)	PRV-C40-D-UNV-T3-BZ MA1017	2	8575
□	S2	1	EATON - LUMARK (FORMER COOPER LIGHTING)	PRV-C40-D-UNV-T4-BZ MA1017	2	8544
□	S3	1	EATON - LUMARK (FORMER COOPER LIGHTING)	PRV-C40-D-UNV-T5-BZ MA1018	2	9130
○	O1	6	LITHONIA LIGHTING	DSXPG LED 10C 1000 40K T5M MVOLT	1	4130
□	W1	7	RZ LIGHTING	WP10-30W	1	3900

S POLES SHALL BE 25' SQUARE STRAIGHT STEEL POLES BY KW INDUSTRIES: SSP25-4.0-7-BRZ-DIM10/2180-BC.
MOUNT POLES ON A 2' CONCRETE POLE BASE. POLES AND LIGHTING FIXTURES TO HAVE A DARK BRONZE FINISH.

Statistics						
Description	Symbol	Avg	Max	Min	Max/Min	Avg/Min
Calc Zone	+	0.8 fc	14.3 fc	0.0 fc	N/A	N/A
Smalls Lot Summary	*	2.2 fc	14.3 fc	0.0 fc	N/A	N/A
Parking Lot Summary	□	2.1 fc	3.9 fc	0.9 fc	4.3:1	2.3:1

PHOTOMETRIC PLAN

A3 SCALE: 1"=20'-0"

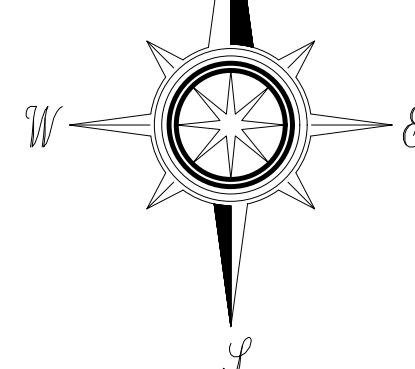

REVISIONS	PROJECT NO:
NO	DATE

SS2507


SHEET

ME1.03

DATE 06.23.2025

SMALLS SLIDERS
101 SW OLDHAM PKWY
LEES SUMMIT, MO 64081

Kurzynske & Associates
CONSULTING ENGINEERS
2705 Lebanon Pike - Suite One
Nashville, Tennessee 37214
Telephone: (615) 255-5203

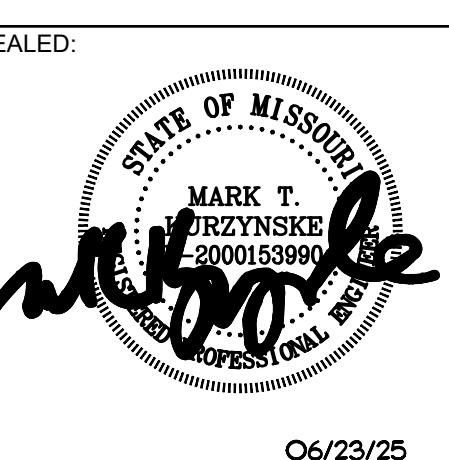

COPYRIGHT
THESE DOCUMENTS ARE PROTECTED BY UNITED STATES
COPYRIGHT LAW. THEY HAVE BEEN PREPARED SPECIFICALLY
FOR THIS PROJECT AND ARE NOT SUITABLE FOR
USE ON ANY OTHER PROJECT OR AT ANY OTHER LOCATION
WITHOUT THE EXPRESS WRITTEN APPROVAL AND
PARTICULAR AGREEMENT OF SMALLS SLIDERS. REPRODUCTION
OF THESE DOCUMENTS MUST BE AUTHORIZED BY SMALLS SLIDERS.
ALL RIGHTS ARE RESERVED TO SMALLS SLIDERS.

SITE PLAN - PHOTOMETRIC PLAN

REVISIONS	PROJECT NO:
NO	DATE

SS2507

SHEET

ME1.03

DATE 06.23.2025