



PRELIMINARY PLAT, PRELIMINARY DEVELOPMENT PLAN AND SPECIAL USE PERMIT LEE'S SUMMIT SENIOR COMMUNITY 5101 NE LAKEWOOD WAY

LEE'S SUMMIT, JACKSON COUNTY, MISSOURI 64064



STARK WILSON DUNCAN ARCHITECTS INC
315 NICHOLS ROAD STE 228 - KANSAS CITY, MO 64112 - T 816.531.1698
WWW.SWDARCHITECTS.COM

GENERAL SITE NOTE

- SITE DESCRIPTION:
 - PRELIMINARY DEVELOPMENT PLAN, PROPOSED LOT 1 AND TRACT 1 OF THE CAPT'N MARF SUBDIVISION PLAT 1 LOCATED IN SECTION 5 T48N R31W, IN LEE'S SUMMIT, JACKSON COUNTY, MISSOURI.
 - SPECIAL USE PERMIT: PROPOSED LOT 1 OF THE CAPT'N MARF SUBDIVISION PLAT 1 LOCATED IN SECTION 5 T48N R31W, IN LEE'S SUMMIT, JACKSON COUNTY, MISSOURI.
 - TOTAL AREA = 16.95 ACRES (LOT 1 = 11.74 AC, TRACT 1 = 5.21 AC)
 - ZONING: CP-2 - PLANNED COMMUNITY COMMERCIAL DISTRICT
 - CURRENT USE: UNDEVELOPED
 - PROPOSED USE: RETIREMENT COMMUNITY AND NURSING HOME/ELDER CARE
 - SPECIAL USE PERMIT (SUP) REQUIRED
 - SITE COVER SUMMARY (LOT 1)
 - BUILDING = 2.56 ACRES (22%)
 - PAVED = 2.94 ACRES (25%)
 - TOTAL OPEN/GREEN SPACE =
 - COMMON OPEN SPACE
 - LOT 1
 - REQUIRED (10%) = 1.11 AC
 - PROVIDED (59%) = 6.29
 - TRACT 1
 - REQUIRED (10%) = 0.52 AC
 - PROVIDED (100%) = 5.21 AC
 - TOTAL IMPERVIOUS 5.5 ACRES
 - PARKING NOTES:
 - REQUIRED PARKING:
 - NURSING HOME/ ELDER CARE - 0.5 PER BED (12 BEDS) = 36 STALLS
 - RETIREMENT COMMUNITY - 1 PER UNIT (104 UNITS) = 104 STALLS
 - EMPLOYEES - 1 PER EMPLOYEE/SHIFT (30 EMPLOYEES) = 30 STALLS
 - TOTAL REQUIRED = 170 STALLS
 - TOTAL PROVIDED = 170 STALLS
- VILLA PARKING
 - REQUIRED = 15 STALLS
 - PROVIDED = 30 STALLS (15 GARAGE AND 15 DRIVEWAY).
- ALL PARKING WILL MEET FAIR HOUSING AND ADA REQUIREMENTS.
- ALL ACCESSIBLE PARKING SHALL BE LESS THAN 1 VERTICAL FOOT IN 50 HORIZONTAL FEET.
- VAN PARKING SPACES SHALL HAVE VERTICAL CLEARANCE OF 88 INCHES MINIMUM AT THE SPACE AND ALONG THE VEHICULAR ROUT THERETO. IN CASES OF A LOADING ZONE, THE VERTICAL CLEARANCE OF 115 INCHES MINIMUM SHALL BE PROVIDED AT PASSENGER LOADING ZONES AND ALONG VEHICLE ACCESS ROUTES TO SUCH AREAS FROM SITE ENTRANCES.
- ALL ONSITE PAVING WILL COMPLY WITH THE UNIFIED DEVELOPMENT ORDINANCE ARTICLE 8 IN TERMS OF PAVING THICKNESS AND BASE.
- FLOODPLAIN NOTE: THIS PROPERTY IS LOCATED IN ZONE "X" AREAS DETERMINED TO BE OUTSIDE THE 0.2% ANNUAL CHANCE FLOODPLAIN, AS SHOWN BY FLOOD INSURANCE RATE MAP NUMBER 2905C0319G, DATED JANUARY 20, 2011.
- NO GAS OR OIL WELLS (INACTIVE OR CAPPED) ARE LOCATED WITHIN THE SITE BOUNDARY PER THE MISSOURI DEPARTMENT OF NATURAL RESOURCES GIS MAP PUBLISHED FEBRUARY 15, 2019 AND UPDATED MARCH 24, 2025.
- NO EXISTING BUILDINGS ARE LOCATED ONSITE.
- HISTORICAL DISTRICT: SITE IS NOT LOCATED INSIDE OF A HISTORICAL DISTRICT.
- NO PROPERTY OR INFRASTRUCTURE ARE LISTED ON THE NATIONAL REGISTRY FOR HISTORIC PLACES.

LAND USE SCHEDULE

	RETIREMENT COMMUNITY (INDEPENDENT SENIOR LIVING)	NURSING HOME/ELDER CARE (ASSISTED LIVING)	MEMORY CARE	VILLA
FLOOR AREA	118,024 SF	45,450 SF	12,546 SF	1,862 SF EA
TOTAL FLOOR AREA	171,020 SF		21,930 SF	
UNITS/BEDS	104 UNITS	52 BEDS	20 BEDS	15 UNITS
LOT 1 + TRACT 1 LAND AREA (ACRES)	16.95 AC			
REQUIRED PARKING	170		15	
PROVIDED PARKING	170		30	
IMPERVIOUS COVERAGE	5.5 AC			
FLOOR AREA RATIO (FAR) WITH COMMON AREA	MAXIMUM ALLOWED = 55 PROVIDED = 34			
DWELLING UNITS PER ACRE DWELLING UNITS PER ACRE WITHOUT COMMON AREA	N/A FOR CP-2			
LOT AREA (LOT 1)	MIN = 40,000 SF PROVIDED = 511,400 SF			
BUILDING AREA/RESIDENT	MIN = 500 SF PROVIDED = 415 SF			

UNIT MATRIX

MEMORY CARE				ACCESSIBLE UNIT TYPES		
UNIT ID	TYPE	QUANTITY	SIZE	ADA ACCESSIBLE	2018 IBC TYPE A	2018 IBC TYPE B
A	STUDIO- 1 BED	14	305 SF			1
A.1	STUDIO- 1 BED	4	316 SF	4		
B	STUDIO- 1 BED	2	305 SF	2		
TOTAL		20		6		1
ASSISTED LIVING						
UNIT ID	TYPE	QUANTITY	SIZE			
C	STUDIO	15	404 SF			15
C.1	STUDIO	3	404 SF	3		
D	STUDIO	2	404 SF	2		
E	1 BEDROOM	21	555 SF			21
E.1	1 BEDROOM	1	555 SF	1		
F	1 BEDROOM	2	555 SF	2		
G	2 BEDROOM	3	805 SF			3
H	2 BEDROOM	1	805 SF	1		
TOTAL		48		9		34
INDEPENDENT LIVING						
UNIT ID	TYPE	QUANTITY	SIZE			
J	STUDIO	15	454 SF			15
J.1	STUDIO	1	454 SF		1	
K	1 BEDROOM	54	678 SF			54
K.1	1 BEDROOM	1	678 SF		1	
L	2 BEDROOM	31	926 SF			31
L.1	2 BEDROOM	1	926 SF		1	
M	2 BEDROOM	1	1143 SF			1
TOTAL		104			3	101
TOTAL UNITS		172				
VILLAS						
UNIT ID	TYPE	QUANTITY	SIZE			
B UNIT	2 BDRM 2 BA	15	1294 SF			
TOTAL UNITS		15				

PROJECT DATA

BUILDING AREA:	
MEMORY CARE	12,546 SF
ASSISTED LIVING	45,450 SF
INDEPENDENT LIVING	118,024 SF
TOTAL	171,020 SF

PROJECT TEAM

ARCHITECT
STARK WILSON DUNCAN ARCHITECTS INC
315 NICHOLS RD, SUITE 228
KANSAS CITY, MISSOURI 64112
816.531.1698

OWNER
O'REILLY DEVELOPMENT CO.
5051 S. NATIONAL AVENUE 4-100
SPRINGFIELD, MO 65810
417.893.6006


MANAGEMENT COMPANY
ARROW SENIOR LIVING
3333-H RUE ROYALE
ST. CHARLES, MO 63301
636.724.1766

CIVIL
ENGINEERING SURVEYS & SERVICES
1115 FAY STREET
COLUMBIA, MO 65201
573.444.2646

SHEET SCHEDULE

00 A	COVERSHEET
CIVIL	
C0.01	OVERALL APPLICATION EXHIBIT
C1.01	PRELIMINARY PLAT
C1.02	EASEMENT EXHIBIT
C1.03	LOTS 2, 3 & 4 DEVELOPMENT EXHIBIT
C2.01	PRELIMINARY DEVELOPMENT PLAN & SPECIAL USE PERMIT SITE PLAN
C2.02	PRELIMINARY DEVELOPMENT PLAN & SPECIAL USE PERMIT GRADING PLAN
C2.03	PRELIMINARY DEVELOPMENT PLAN & SPECIAL USE PERMIT UTILITY PLAN
C3.01	SIGHT DISTANCE EXHIBIT
LANDSCAPE	
L1.0	LANDSCAPE PLAN
L1.1	LANDSCAPE PLAN ENLARGEMENT 1
L1.2	LANDSCAPE PLAN ENLARGEMENT 2
L1.3	LANDSCAPE PLAN ENLARGEMENT 3
ARCHITECTURAL	
SP1.1	SITE DETAILS
SP1.2	SITE DETAILS
SP1.3	SITE DETAILS
A1.1	OVERALL LOWER FLOOR PLAN
A1.2	OVERALL FIRST FLOOR PLAN
A1.3	OVERALL SECOND FLOOR PLAN
A1.4	OVERALL FLOOR PLAN - VILLA
A2.1	BUILDING ELEVATIONS
A2.2	BUILDING ELEVATIONS
A2.3	BUILDING ELEVATIONS - VILLA
ELECTRICAL	
PH.1	PHOTOMETRIC SITE PLAN


ISSUE DATE:
1.26.2026

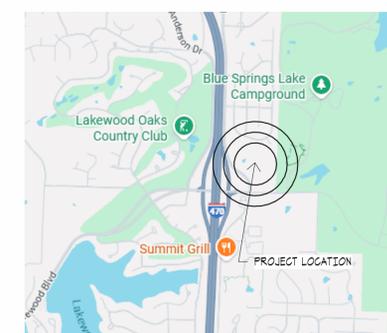

LOCATION MAP



NORTH

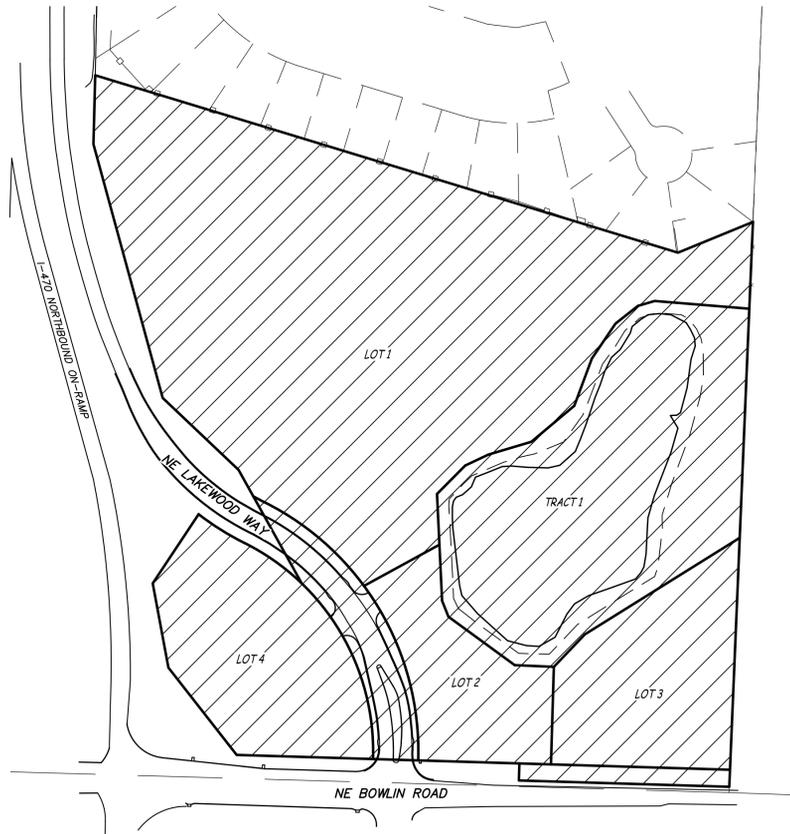

PRELIMINARY PLAT

SCALE: 1" = 150'


PROPERTY DESCRIPTION

PARCEL 1

ALL THAT PART OF THE NORTHEAST QUARTER OF SECTION 5, TOWNSHIP 48, RANGE 31 IN LEE'S SUMMIT, JACKSON COUNTY, MISSOURI, DESCRIBED AS FOLLOWS: BEGINNING AT A POINT ON THE EAST LINE OF THE NORTHEAST QUARTER OF SECTION 5, TOWNSHIP 48, RANGE 31, SAID POINT LYING 1630.07 FEET SOUTH OF THE NORTHEAST CORNER OF SAID NORTHEAST QUARTER; THENCE SOUTH 02 DEGREES 24 MINUTES 42 SECONDS WEST ALONG THE EAST LINE OF SAID NORTHEAST QUARTER A DISTANCE OF 985.69 FEET (DEED READS 985.91 FEET) TO THE NORTH RIGHT OF WAY LINE OF BOWLIN ROAD; THENCE NORTH 88 DEGREES 16 MINUTES 57 SECONDS WEST ALONG THE NORTH RIGHT OF WAY LINE OF BOWLIN ROAD A DISTANCE OF 372.37 FEET (DEED READS NORTH 88 DEGREES 16 MINUTES 57 SECONDS WEST A DISTANCE OF 372.23 FEET); THENCE CONTINUING ALONG THE NORTH RIGHT OF WAY LINE OF BOWLIN ROAD AND THE EAST RIGHT OF WAY LINE OF U.S. INTERSTATE HIGHWAY 470 AS FOLLOWS: THENCE NORTH 01 DEGREES 43 MINUTES 01 SECONDS EAST A DISTANCE OF 30.00 FEET; THENCE NORTH 88 DEGREES 16 MINUTES 59 SECONDS WEST A DISTANCE OF 210.12 FEET; THENCE NORTH 43 DEGREES 37 MINUTES 04 SECONDS WEST A DISTANCE OF 137.30 FEET TO A POINT LOCATED 690.00 FEET EAST OF STA 755+40 OF THE CENTERLINE OF INTERSTATE 470 AS NOW ESTABLISHED; THENCE NORTH 17 DEGREES 59 MINUTES 21 SECONDS WEST A DISTANCE OF 170.88 FEET TO A POINT LOCATED 630.00 FEET EAST OF CENTERLINE STA 757+00; THENCE NORTH 29 DEGREES 15 MINUTES 44 SECONDS WEST A DISTANCE OF 285.18 FEET TO A POINT LOCATED 480.00 FEET EAST OF CENTERLINE STA 759+0040; THENCE NORTH 46 DEGREES 40 MINUTES 00 SECONDS WEST A DISTANCE OF 184.56 FEET TO A POINT LOCATED 341.25 FEET EAST OF CENTERLINE STA 760+60; THENCE NORTH 15 DEGREES 19 MINUTES 37 SECONDS WEST A DISTANCE OF 463.37 FEET TO A POINT LOCATED 205.00 FEET EAST OF STA 765+00; THENCE NORTH 01 DEGREES 29 MINUTES 56 SECONDS EAST A DISTANCE OF 121.38 FEET (DEED READS 121.56 FEET) TO A POINT LOCATED 205.00 FEET EAST OF CENTERLINE STA 766+21.56; THENCE LEAVING THE EAST RIGHT OF WAY LINE OF U.S. INTERSTATE HIGHWAY 470, SOUTH 73 DEGREES 08 MINUTES 55 SECONDS EAST A DISTANCE OF 1077.29 FEET (DEED READS 1077.15 FEET); THENCE NORTH 67 DEGREES 49 MINUTES 27 SECONDS EAST A DISTANCE OF 143.23 FEET TO THE POINT OF BEGINNING. EXCEPT THAT PART TAKEN FOR STREETS OR ROADS.

PARCEL 2

COMMENCING AT THE INTERSECTION OF THE NORTH RIGHT-OF-WAY LINE OF BOWLIN ROAD AND THE NORTHEASTERLY RIGHT OF WAY OF THE INTERSTATE ROUTE 470, AS THE SAME ARE NOW ESTABLISHED; THENCE NORTH 43 DEGREES 30 MINUTES 50 SECONDS WEST ALONG SAID NORTHEASTERLY RIGHT OF WAY LINE, A DISTANCE OF 72.41 FEET TO THE POINT OF BEGINNING OF THE TRACT OF LAND TO BE HEREIN DESCRIBED; THENCE CONTINUING NORTH 43 DEGREES 30 MINUTES 50 SECONDS WEST ALONG SAID NORTHEASTERLY RIGHT OF WAY LINE, A DISTANCE OF 64.97 FEET; THENCE NORTH 17 DEGREES 51 MINUTES 02 SECONDS WEST ALONG SAID NORTHEASTERLY RIGHT OF WAY LINE, A DISTANCE OF 170.88 FEET; THENCE NORTH 29 DEGREES 07 MINUTES 26 SECONDS WEST ALONG SAID NORTHEASTERLY RIGHT OF WAY LINE, A DISTANCE OF 54.57 FEET; THENCE NORTHWESTERLY, DEPARTING ALONG SAID NORTHEASTERLY RIGHT OF WAY LINE, ALONG A CURVE TO THE LEFT, HAVING AN INITIAL TANGENT BEARING OF NORTH 46 DEGREES 02 MINUTES 32 SECONDS WEST, A RADIUS OF 410.00 FEET AND A CENTRAL ANGLE OF 17 DEGREES 33 MINUTES 30 SECONDS, AN ARC DISTANCE OF 125.64 FEET; THENCE NORTHWESTERLY ALONG A CURVE TO THE RIGHT, HAVING A COMMON TANGENT WITH THE LAST DESCRIBED COURSE, A RADIUS OF 490.00 FEET AND A CENTRAL ANGLE OF 11 DEGREES 08 MINUTES 36 SECONDS, AN ARC DISTANCE OF 95.30 FEET; THENCE SOUTH 33 DEGREES 49 MINUTES 16 SECONDS WEST, A DISTANCE OF 145.22 FEET; THENCE SOUTH 10 DEGREES 27 MINUTES 49 SECONDS EAST, A DISTANCE OF 150.04 FEET; THENCE SOUTH 39 DEGREES 00 MINUTES 56 SECONDS EAST, A DISTANCE OF 195.45 FEET; THENCE SOUTH 88 DEGREES 08 MINUTES 41 SECONDS EAST A DISTANCE OF 241.38 FEET; THENCE NORTHERLY AND NORTHWESTERLY ALONG A CURVE TO THE LEFT, HAVING AN INITIAL TANGENT BEARING OF NORTH 01 DEGREES 51 MINUTES 05 SECONDS EAST, A RADIUS OF 410.00 FEET AND A CENTRAL ANGLE OF 7 DEGREES 07 MINUTES 39 SECONDS, AN ARC DISTANCE OF 51.00 FEET TO THE POINT OF BEGINNING.

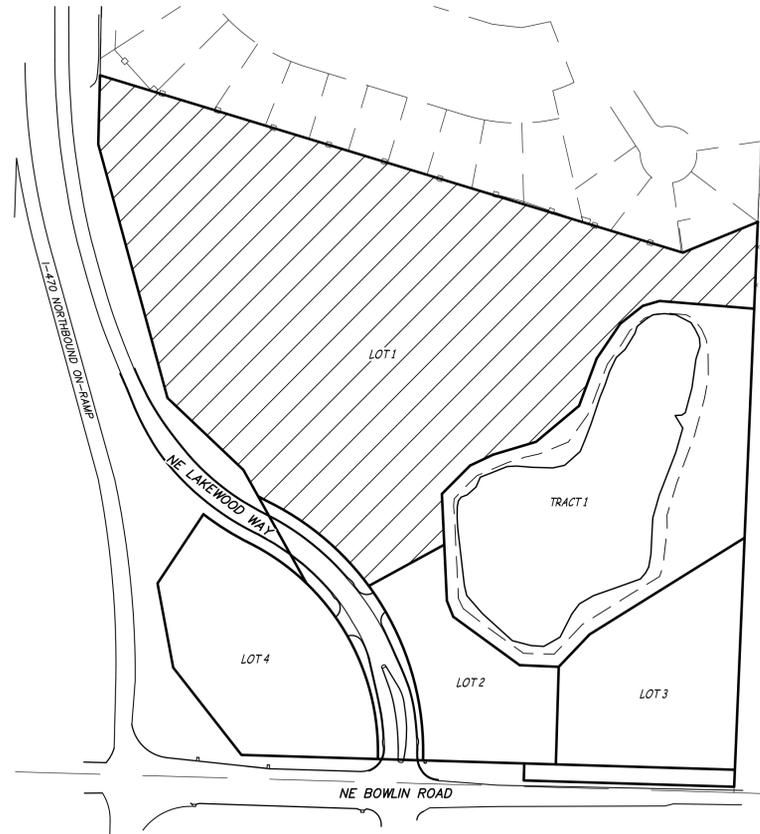


SPECIAL USE PERMIT

SCALE: 1" = 150'

PROPERTY DESCRIPTION

PROPOSED LOT 1 OF THE CAPT'N WARF SUBDIVISION PLAT 1 LOCATED IN SECTION 5 T48N R31W, IN LEE'S SUMMIT, JACKSON COUNTY, MISSOURI.

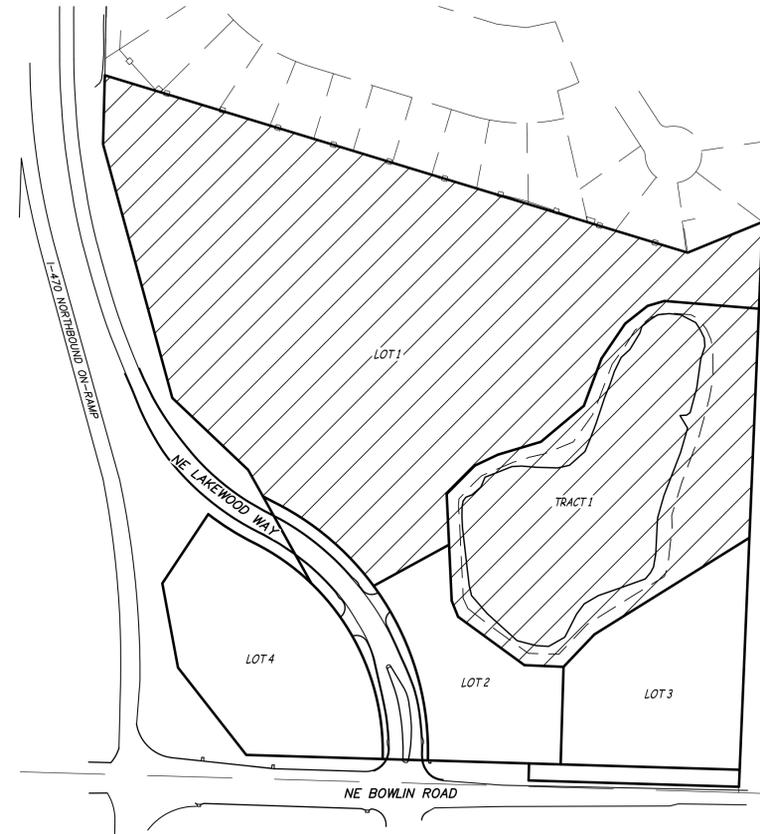

PRELIMINARY DEVELOPMENT PLAN

SCALE: 1" = 150'

PROPERTY DESCRIPTION

PROPOSED LOT 1 AND TRACT 1 OF THE CAPT'N WARF SUBDIVISION PLAT 1 LOCATED IN SECTION 5 T48N R31W, IN LEE'S SUMMIT, JACKSON COUNTY, MISSOURI.



ARCHITECTURAL CORPORATION
MISSOURI CERTIFICATE
OF AUTHORITY NO. 000073

PRELIMINARY PLAT
CAPT'S WHARF SUBDIVISION
NE LAKEWOOD WAY & NE BOWLIN ROAD
LEES SUMMIT, JACKSON COUNTY, MISSOURI 64064

STARK WILSON DUNCAN ARCHITECTS INC
315 NICHOLS RD. STE 228 - KANSAS CITY, MO 64112 - T 816.531.1696 - WWW.SWDARCHITECTS.COM



OVERALL APPLICATION
EXHIBIT

ISSUE DATE:


1.26.2026

REVISIONS:



PROJECT NO.: 2510
C0.01
MISSOURI ENGINEERING CORP. # 2004005018
ES&S PROJECT NO. 16803
COPYRIGHT © 2025 SWD ARCHITECTS INC.

\\192.168.0.991\Projects\General\Projects\16803-SWD-Lees-Summit-Senior-CDs\CAD\16803 PRE PLAT.dwg
Jan 26, 2026 5:25pm

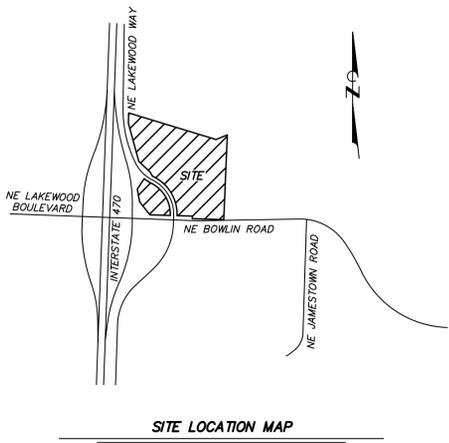

SITE LOCATION MAP
NOT TO SCALE

LEGEND

---	PROPERTY LINE
---	ADJOINING PROPERTY LINE
---	SECTION LINE
---	ELECTRIC LINE
---	UNDERGROUND ELECTRIC LINE
---	SANITARY SEWER LINE
---	STORM SEWER LINE
---	GAS LINE
---	WATER LINE
---	WOODEN FENCE
---	BARB WIRE FENCE
---	EXISTING CONTOUR
---	ANCHOR
---	FOUND SURVEY MONUMENT
---	SET 1/2" REBAR & CAP
---	FOUND R/W MARKER
---	UTILITY POLE
---	PULLBOX
---	PROPOSED PROPERTY LINE
---	PROPOSED SANITARY SEWER LINE
---	PROPOSED WATER LINE
---	PROPOSED UNDERGROUND ELECTRIC
---	PROPOSED STORM SEWER
---	PROPOSED CONCRETE CURB & GUTTER
---	PROPOSED FIRE HYDRANT
---	PROPOSED HIGH DENSITY POLYETHYLENE PIPE

PROPERTY OWNER	ZONING NOTE
CAPTAIN'S WHARF, L.L.C. 208 ASPEN COURT LEES SUMMIT, MISSOURI, 64064	THIS PROPERTY IS ZONED "CP-2" PLANNED COMMUNITY COMMERCIAL

FLOODPLAIN NOTE
THIS PROPERTY IS LOCATED IN ZONE "X" AREAS DETERMINED TO BE OUTSIDE THE 0.2% ANNUAL CHANCE FLOODPLAIN, AS SHOWN BY FLOOD INSURANCE RATE MAP NUMBER 29095C0313G, DATED JANUARY 20, 2017.

PROPERTY DESCRIPTION

PARCEL 1
ALL THAT PART OF THE NORTHEAST QUARTER OF SECTION 5, TOWNSHIP 48, RANGE 31 IN LEE'S SUMMIT, JACKSON COUNTY, MISSOURI, DESCRIBED AS FOLLOWS: BEGINNING AT A POINT ON THE EAST LINE OF THE NORTHEAST QUARTER OF SECTION 5, TOWNSHIP 48, RANGE 31, SAID POINT LYING 163.07 FEET SOUTH OF THE NORTHEAST CORNER OF SAID NORTHEAST QUARTER; THENCE SOUTH 02 DEGREES 24 MINUTES 42 SECONDS WEST ALONG THE EAST LINE OF SAID NORTHEAST QUARTER A DISTANCE OF 995.69 FEET (DEED READS 995.91 FEET) TO THE NORTH RIGHT OF WAY LINE OF BOWLIN ROAD; THENCE NORTH 88 DEGREES 16 MINUTES 57 SECONDS WEST ALONG THE NORTH RIGHT OF WAY LINE OF BOWLIN ROAD A DISTANCE OF 372.23 FEET; THENCE CONTINUING ALONG THE NORTH RIGHT OF WAY LINE OF BOWLIN ROAD AND THE EAST RIGHT OF WAY LINE OF U.S. INTERSTATE HIGHWAY 470 AS FOLLOWS: THENCE NORTH 01 DEGREES 43 MINUTES 01 SECONDS EAST A DISTANCE OF 30.00 FEET; THENCE NORTH 88 DEGREES 16 MINUTES 59 SECONDS WEST A DISTANCE OF 210.12 FEET; THENCE NORTH 43 DEGREES 37 MINUTES 04 SECONDS WEST A DISTANCE OF 137.30 FEET TO A POINT LOCATED 690.00 FEET EAST OF STA 754+40 OF THE CENTERLINE OF INTERSTATE 470 AS NOW ESTABLISHED; THENCE NORTH 17 DEGREES 59 MINUTES 21 SECONDS WEST A DISTANCE OF 170.88 FEET TO A POINT LOCATED 630.00 FEET EAST OF CENTERLINE STA 754+00; THENCE NORTH 29 DEGREES 15 MINUTES 44 SECONDS WEST A DISTANCE OF 285.18 FEET TO A POINT LOCATED 480.00 FEET EAST OF CENTERLINE STA 759+00; THENCE NORTH 46 DEGREES 40 MINUTES 00 SECONDS WEST A DISTANCE OF 184.58 FEET TO A POINT LOCATED 341.25 FEET EAST OF CENTERLINE STA 760+60; THENCE NORTH 15 DEGREES 19 MINUTES 37 SECONDS WEST A DISTANCE OF 463.37 FEET TO A POINT LOCATED 205.00 FEET EAST OF STA 768+00; THENCE NORTH 01 DEGREES 29 MINUTES 56 SECONDS EAST A DISTANCE OF 121.38 FEET (DEED READS 121.56 FEET) TO A POINT LOCATED 205.00 FEET EAST OF CENTERLINE STA 768+21.56; THENCE LEAVING THE EAST RIGHT OF WAY LINE OF U.S. INTERSTATE HIGHWAY 470, SOUTH 73 DEGREES 08 MINUTES 55 SECONDS EAST A DISTANCE OF 1077.29 FEET (DEED READS 1077.15 FEET); THENCE NORTH 67 DEGREES 49 MINUTES 27 SECONDS EAST A DISTANCE OF 143.23 FEET TO THE POINT OF BEGINNING, EXCEPT THAT PART TAKEN FOR STREETS OR ROADS.

PARCEL 2
COMMENCING AT THE INTERSECTION OF THE NORTH RIGHT-OF-WAY LINE OF BOWLIN ROAD AND THE NORTHEASTERLY RIGHT OF WAY OF THE INTERSTATE ROUTE 470 AS THE SAME ARE NOW ESTABLISHED; THENCE NORTH 43 DEGREES 30 MINUTES 50 SECONDS WEST ALONG SAID NORTHEASTERLY RIGHT OF WAY LINE, A DISTANCE OF 72.41 FEET TO THE POINT OF BEGINNING OF THE TRACT OF LAND TO BE HEREIN DESCRIBED; THENCE CONTINUING NORTH 43 DEGREES 30 MINUTES 50 SECONDS WEST ALONG SAID NORTHEASTERLY RIGHT OF WAY LINE, A DISTANCE OF 64.97 FEET; THENCE NORTH 17 DEGREES 51 MINUTES 02 SECONDS WEST ALONG SAID NORTHEASTERLY RIGHT OF WAY LINE, A DISTANCE OF 170.88 FEET; THENCE NORTH 29 DEGREES 15 MINUTES 44 SECONDS WEST ALONG SAID NORTHEASTERLY RIGHT OF WAY LINE, A DISTANCE OF 54.57 FEET; THENCE NORTHWESTERLY, DEPARTING ALONG SAID NORTHEASTERLY RIGHT OF WAY LINE, ALONG A CURVE TO THE LEFT, HAVING AN INITIAL TANGENT BEARING OF NORTH 46 DEGREES 02 MINUTES 32 SECONDS WEST, A RADIUS OF 410.00 FEET AND A CENTRAL ANGLE OF 17 DEGREES 33 MINUTES 30 SECONDS, AN ARC DISTANCE OF 125.64 FEET; THENCE NORTHWESTERLY ALONG A CURVE TO THE RIGHT, HAVING A COMMON TANGENT WITH THE LAST DESCRIBED CURVE, A RADIUS OF 490.00 FEET AND A CENTRAL ANGLE OF 11 DEGREES 08 MINUTES 36 SECONDS, AN ARC DISTANCE OF 95.30 FEET; THENCE SOUTH 33 DEGREES 49 MINUTES 16 SECONDS EAST, A DISTANCE OF 145.22 FEET; THENCE SOUTH 10 DEGREES 27 MINUTES 49 SECONDS EAST, A DISTANCE OF 150.94 FEET; THENCE SOUTH 38 DEGREES 00 MINUTES 56 SECONDS EAST, A DISTANCE OF 106.45 FEET; THENCE SOUTH 88 DEGREES 08 MINUTES 41 SECONDS EAST A DISTANCE OF 241.38 FEET; THENCE NORTHERLY AND NORTHEASTERLY ALONG A CURVE TO THE LEFT, HAVING AN INITIAL TANGENT BEARING OF NORTH 01 DEGREES 51 MINUTES 05 SECONDS EAST, A RADIUS OF 410.00 FEET AND A CENTRAL ANGLE OF 7 DEGREES 07 MINUTES 39 SECONDS, AN ARC DISTANCE OF 51.00 FEET TO THE POINT OF BEGINNING.

PHASING SCHEDULE NOTE
PLAT 1 - LOT 1 AND TRACT 1 INCLUDING WATER MAIN ALONG LAKEWOOD WAY, SEWER MAIN, & ADJACENT IMPROVEMENTS.
PLAT 2 - LOT 2, 3, AND 4 INCLUDING ADJACENT IMPROVEMENTS.

SETBACK NOTE
FRONT SETBACK = 15'
REAR SETBACK = 20'
SIDE SETBACK = 10' FEET (0' INTERIOR LOT LINES)

- GENERAL NOTES**
- SITE AREA = 22.22 ACRES
 - ZONING = CP-2 - PLANNED COMMUNITY COMMERCIAL DISTRICT
 - CURRENT USE: UNDEVELOPED
 - NO EXISTING BUILDINGS ARE LOCATED ON-SITE. THE NORTHERN SITE BOUNDARY IS MADE UP OF A NEIGHBORHOOD OF SINGLE FAMILY HOMES.
 - HISTORICAL DISTRICT: SITE IS NOT LOCATED INSIDE OF A HISTORICAL DISTRICT.
 - NO PROPERTY OR INFRASTRUCTURE ARE LISTED ON THE NATIONAL REGISTER FOR HISTORIC PLACE
 - NO GAS OR OIL WELLS (INACTIVE OR CAPPED) ARE LOCATED WITHIN THE SITE BOUNDARIES PER THE MISSOURI DEPARTMENT OF NATURAL RESOURCES GIS MAP PUBLISHED FEBRUARY 15, 2019 AND UPDATED MARCH 24, 2025.
 - STORM WATER MANAGEMENT
 - WATERSHED: WHITE RIVER
 - COMMON DETENTION FOR LOTS 1 THRU 4 WILL BE PROVIDED VIA THE POND LOCATED ON THE 5.21 ACRE COMMON LOT.
 - THE EXISTING POND WILL BE PARTIALLY FILLED TO ALLOW THE LOTS ADJACENT TO NE BOWLIN ROAD TO HAVE ADEQUATE DEVELOPMENT AREA.
 - THE 100 YEAR POND ELEVATION TO BE A MINIMUM OF 20' OFFSET FROM ALL SURROUNDING PROPERTY LINES.
 - ENCLOSED PIPES AND INLETS AND ENGINEERED SWALES WILL COLLECT AND CONVEY ON-SITE STORM RUNOFF INTO THE EXISTING DETENTION BASIN.
 - WATER AND SEWER
 - WATER AND SEWER PROVIDED BY CITY OF LEE'S SUMMIT
 - ANTICIPATED SEWER DEMAND:
 - PEAK BASE FLOW = 0.4 EDU * 191 UNITS = 22,920 GPD
 - PEAK FLOW: 22,920 GPD + (250 GPD/AC * 11.74 AC) + (0.003 * 3.59 IN/HR * 11.74 AC * 646,317 GPD/CFS) = 107,575 GPD
 - TO REMOVE THE IMPACT OF A SANITARY LINE IN THE COMMON LOT, A PORTION OF EXISTING SANITARY LINE ABANDONED IN PLACE WITH NEW LINE RELOCATED OUT OF COMMON DETENTION LOT.
 - ANTICIPATED WATER DEMAND:
 - DAILY = 191 UNITS * 125 GPD/PERSON * 2.78 PERSONS/UNIT = 66,373 GPD
 - MAXIMUM DAILY WATER DEMAND = 66,373 GPD * 2.2 = 146,020 GPD
 - PEAK HOUR DEMAND = 2 * 146,020 GPD/3600 MINS/DAY = 81 GPM
 - SITE SHALL BE DESIGNED IN ACCORDANCE WITH THE 2018 INTERNATIONAL FIRE CODE
 - THERE ARE NO KNOWN DOWNSTREAM SEWER CAPACITY LIMITATIONS.
 - GRANTOR, ON BEHALF OF HIMSELF, HIS HEIRS, HIS ASSIGNS AND SUCCESSORS IN INTEREST, HEREBY WAIVES, TO THE FULLEST EXTENT ALLOWED BY LAW, INCLUDING, WITHOUT LIMITATION, SECTION 527.188 RSMO. (2006), ANY RIGHT TO REQUEST RESTORATION OF RIGHTS PREVIOUSLY TRANSFERRED AND VACATION OF THE EASEMENT HEREIN GRANTED.


I:\192.168.0.99\Projects\General\Projects\16803-SWD-Lees-Summit-Senior-CDOs\CAD\16803 PRE PLAT.dwg
Feb 09, 2026 3:13pm



ARCHITECTURAL CORPORATION
MISSOURI CERTIFICATE
OF AUTHORITY NO. 000073

PRELIMINARY PLAT
CAPT'S WHARF SUBDIVISION
NE LAKEWOOD WAY & NE BOWLIN ROAD
LEES SUMMIT, JACKSON COUNTY, MISSOURI 64064

STARK WILSON DUNCAN ARCHITECTS INC
315 NICHOLS RD. STE 228 - KANSAS CITY, MO 64112 - T 816.531.1698 - WWW.SWDARCHITECTS.COM

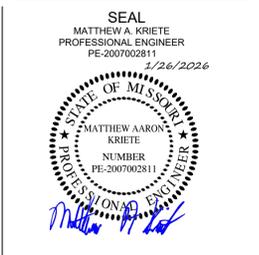

EASEMENT EXHIBIT

ISSUE DATE:
1.26.2026
REVISIONS:
REVISION - 02/04/2026

PROJECT NO.: 2510

C1.02

COPYRIGHT © 2025 SWD ARCHITECTS INC.




Parcel 1
5101 NE Lakewood Way
Lee's Summit, MO
Owner:
Captain's Wharf LLC
208 Aspen Court
Lee's Summit, MO
Doc. No. 2007E0046152

Parcel 2
Owner:
Captain's Wharf LLC
208 Aspen Court
Lee's Summit, MO
Doc. No. 2007E0046152

VACATE
Easement Per
Doc#1237979
Exception#12

VACATE
Easement Per
Doc#2007E0045988
Exception#14

\\192.168.0.99\Projects\General Projects\16803-SWD-Lees-Summit-Senior-CDs\CAD\16803 PRE PLAT.dwg
Feb 09, 2026 3:13pm

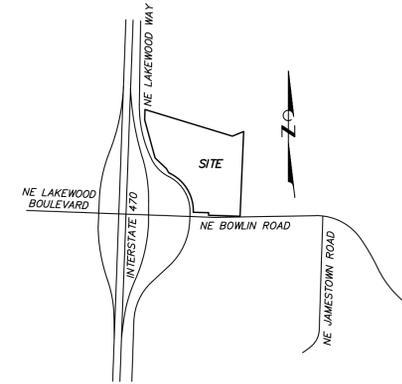

SITE LOCATION MAP

NOT TO SCALE

PROPERTY OWNER

CAPTAIN'S WHARF, L.L.C.
208 NW ASPEN COURT
LEE'S SUMMIT, MISSOURI, 64064

ZONING NOTE

THIS PROPERTY IS ZONED "CP-2"
PLANNED COMMUNITY COMMERCIAL

PROPERTY DESCRIPTION

FOR PRELIMINARY DEVELOPMENT PLAN:
PROPOSED LOT 1 AND TRACT 1 OF THE CAPT'N WHARF SUBDIVISION PLAT 1
LOCATED IN SECTION 5 T48N R31W, IN LEE'S SUMMIT, JACKSON COUNTY,
MISSOURI.

FOR SPECIAL USE PERMIT:
PROPOSED LOT 1 OF THE CAPT'N WHARF SUBDIVISION PLAT 1 LOCATED IN
SECTION 5 T48N R31W, IN LEE'S SUMMIT, JACKSON COUNTY, MISSOURI.

LEGEND

○	PROPERTY LINE	○	ADJOINING PROPERTY LINE
—	SECTION LINE	—	PROPOSED BACK OF CURB
—	ELECTRIC LINE	—	PROPOSED CONCRETE CURB & GUTTER
—	UNDERGROUND ELECTRIC LINE	—	PROPOSED CONCRETE SIDEWALK
—	SANITARY SEWER LINE	—	PROPOSED CURB INLET
—	STORM SEWER LINE	—	PROPOSED CLEANOUT
—	GAS LINE	—	PROPOSED DRAIN BASIN
—	WOODEN FENCE	—	PROPOSED FLARED END SECTION
—	BARB WIRE FENCE	—	PROPOSED HIGH-PERFORMANCE PIPE
—	EXISTING CONTOUR	—	PROPOSED HIGH DENSITY POLYETHYLENE PIPE
—	ANCHOR	—	PROPOSED INLINE DRAIN
—	FOUND SURVEY MONUMENT	—	PROPOSED JUNCTION BOX
—	SET 1/2" REBAR & CAP	—	PROPOSED LIGHT STANDARD
—	FOUND R/W MARKER	—	PROPOSED MANHOLE
—	UTILITY POLE	—	PROPOSED POLE LIGHT
—	PULLBOX	—	PROPOSED POLYVINYL CHLORIDE PIPE
—	PROPOSED AREA INLET	—	PROPOSED ROLLBACK CURB & GUTTER
—	PROPOSED BACK OF CURB	—	PROPOSED REINFORCED CONCRETE PIPE
—	PROPOSED CONCRETE CURB & GUTTER	—	PROPOSED WATER METER
—	PROPOSED CONCRETE SIDEWALK	—	PROPOSED WATER VALVE
—	PROPOSED CURB INLET		
—	PROPOSED CLEANOUT		
—	PROPOSED DRAIN BASIN		
—	PROPOSED FLARED END SECTION		
—	PROPOSED HIGH-PERFORMANCE PIPE		
—	PROPOSED HIGH DENSITY POLYETHYLENE PIPE		
—	PROPOSED INLINE DRAIN		
—	PROPOSED JUNCTION BOX		
—	PROPOSED LIGHT STANDARD		
—	PROPOSED MANHOLE		
—	PROPOSED POLE LIGHT		
—	PROPOSED POLYVINYL CHLORIDE PIPE		
—	PROPOSED ROLLBACK CURB & GUTTER		
—	PROPOSED REINFORCED CONCRETE PIPE		
—	PROPOSED WATER METER		
—	PROPOSED WATER VALVE		

FLOODPLAIN NOTE


THIS PROPERTY IS LOCATED IN ZONE "X" AREAS DETERMINED TO BE
OUTSIDE THE 0.2% ANNUAL CHANCE FLOODPLAIN, AS SHOWN BY FLOOD
INSURANCE RATE MAP NUMBER 29095C0313G, DATED JANUARY 20, 2017.



PROJECT NO.: 2510

C2.01

COPYRIGHT © 2025 SWD ARCHITECTS INC.

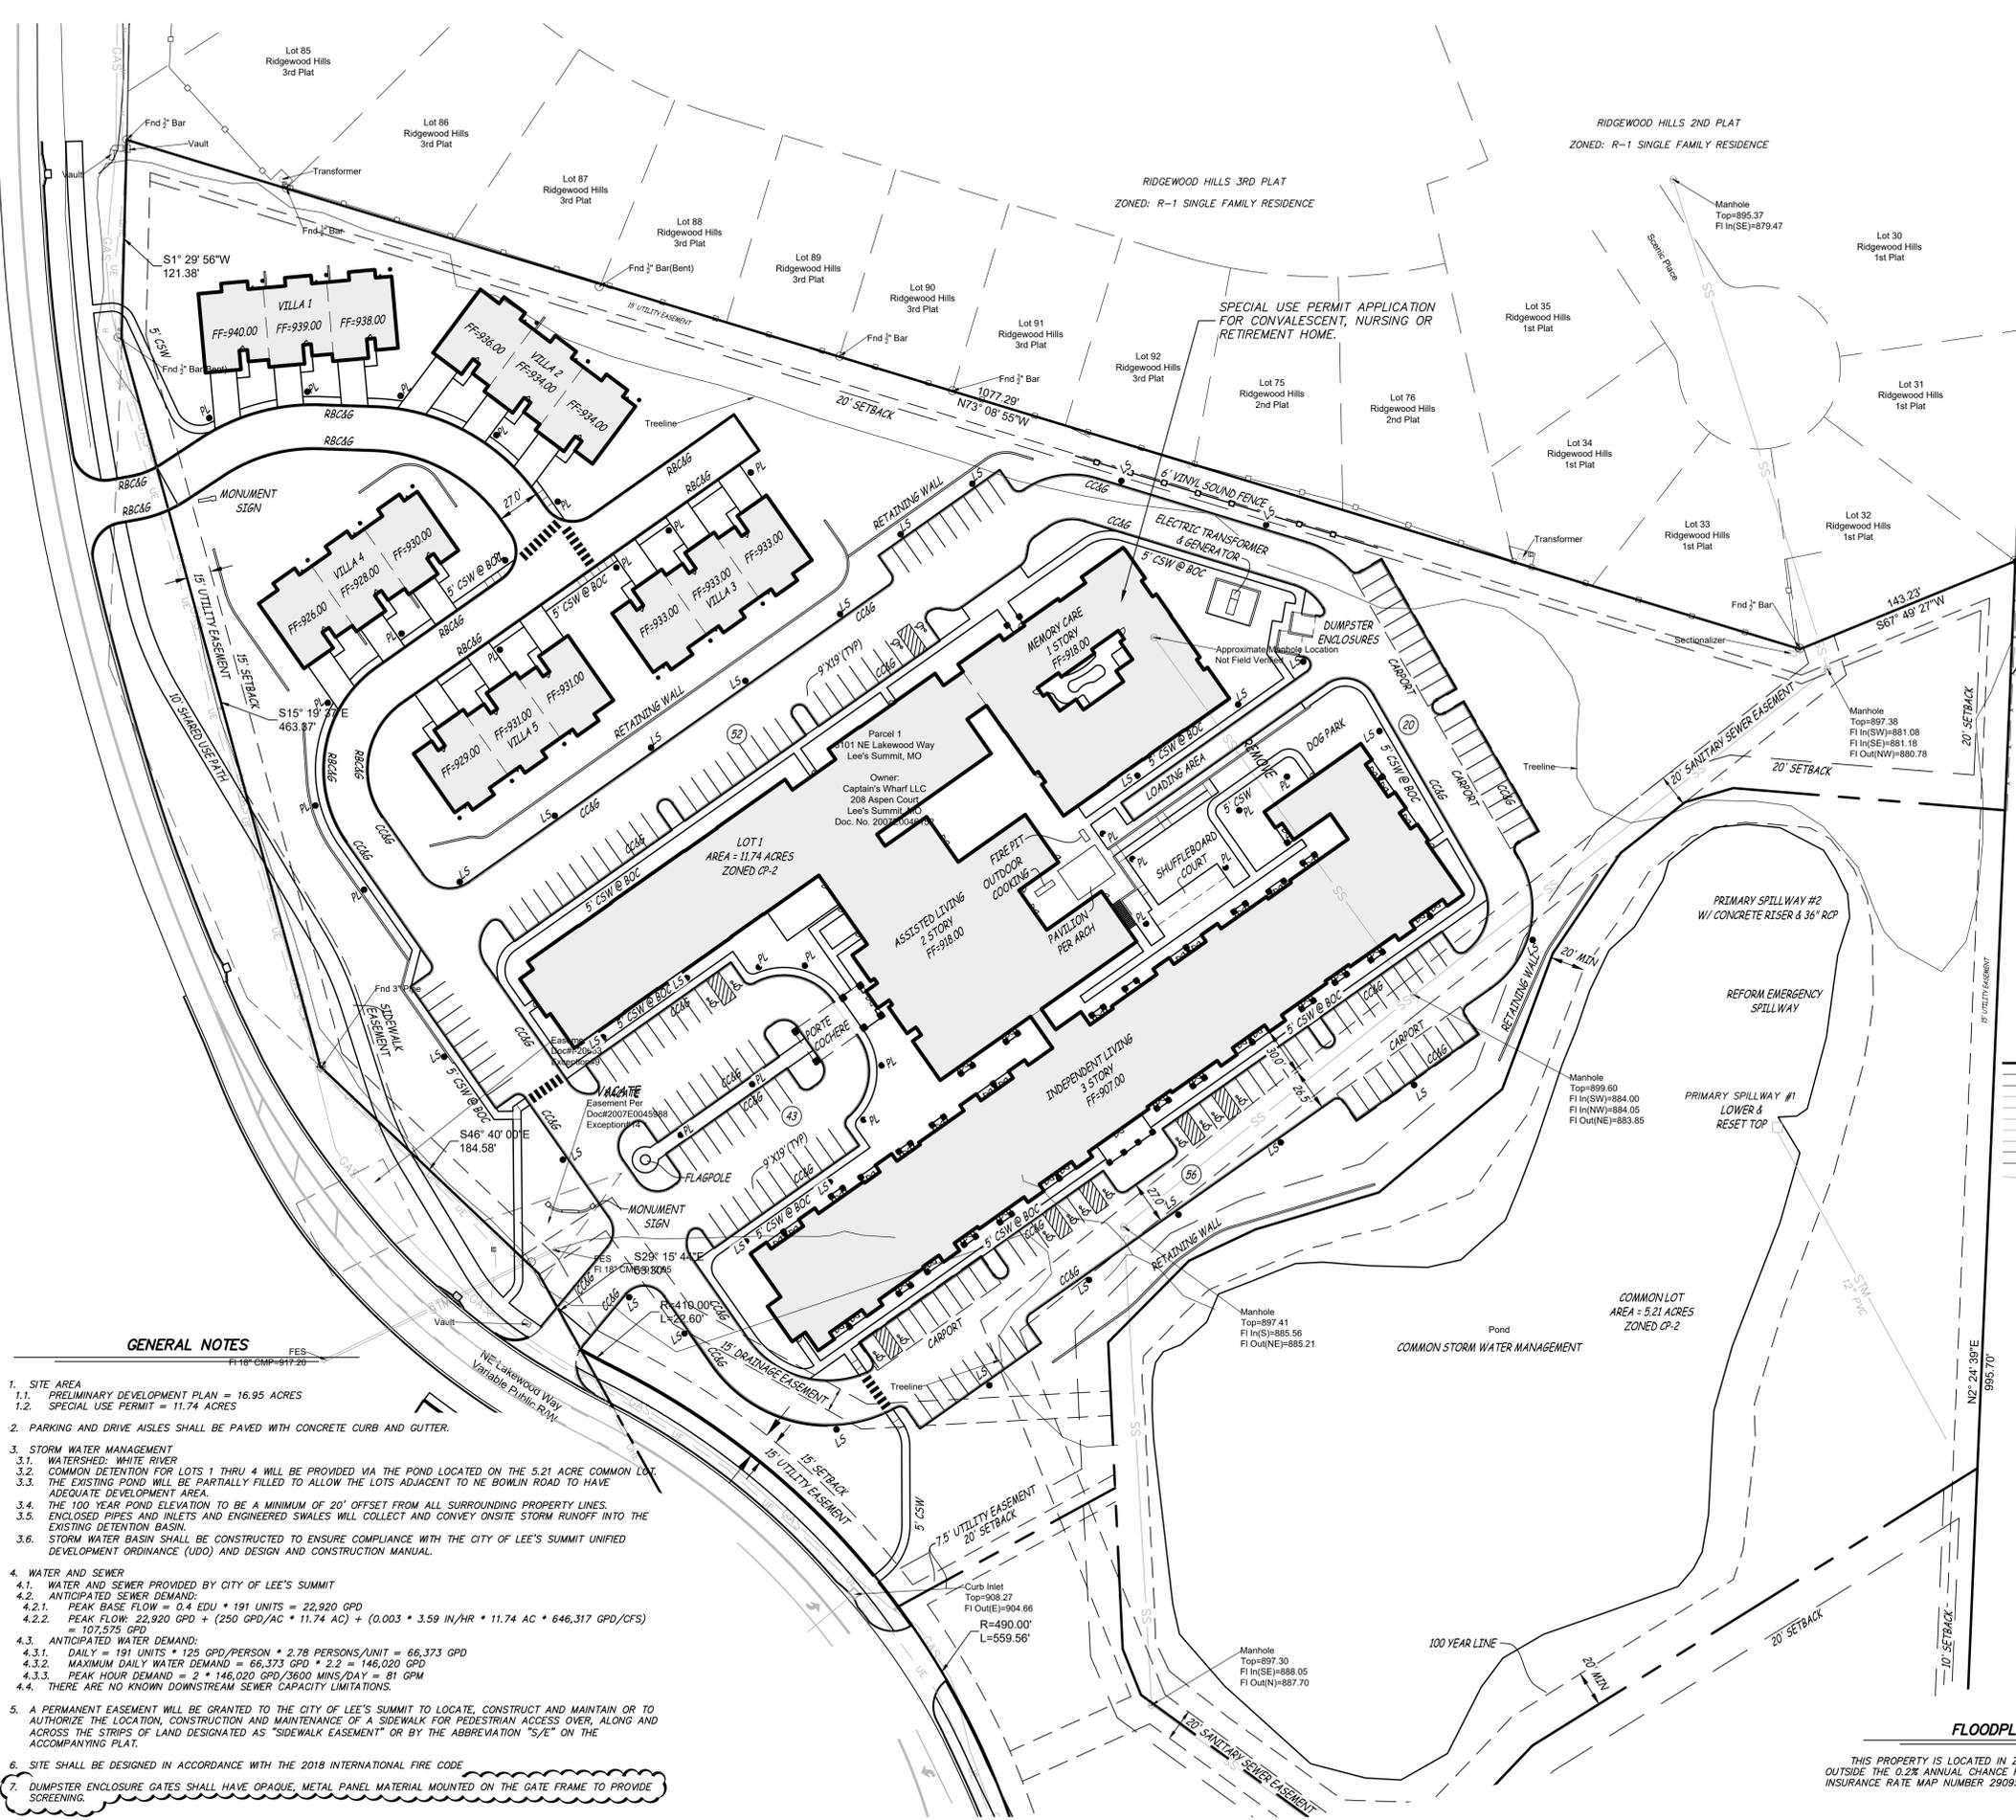


GENERAL NOTES

- SITE AREA
 - PRELIMINARY DEVELOPMENT PLAN = 16.95 ACRES
 - SPECIAL USE PERMIT = 11.74 ACRES
- PARKING AND DRIVE AISLES SHALL BE PAVED WITH CONCRETE CURB AND GUTTER.
- STORM WATER MANAGEMENT
 - WATERSHED: WHITE RIVER
 - COMMON DETENTION FOR LOTS 1 THRU 4 WILL BE PROVIDED VIA THE POND LOCATED ON THE 5.21 ACRE COMMON LOT.
 - THE EXISTING POND WILL BE PARTIALLY FILLED TO ALLOW THE LOTS ADJACENT TO NE BOWLIN ROAD TO HAVE ADEQUATE DEVELOPMENT AREA.
 - THE 100 YEAR POND ELEVATION TO BE A MINIMUM OF 20' OFFSET FROM ALL SURROUNDING PROPERTY LINES.
 - ENCLOSED PIPES AND INLETS AND ENGINEERED SWALES WILL COLLECT AND CONVEY ONSITE STORM RUNOFF INTO THE EXISTING DETENTION BASIN.
 - STORM WATER BASIN SHALL BE CONSTRUCTED TO ENSURE COMPLIANCE WITH THE CITY OF LEE'S SUMMIT UNIFIED DEVELOPMENT ORDINANCE (UDO) AND DESIGN AND CONSTRUCTION MANUAL.
- WATER AND SEWER
 - WATER AND SEWER PROVIDED BY CITY OF LEE'S SUMMIT
 - ANTICIPATED SEWER DEMAND:
 - PEAK BASE FLOW = 0.4 EDU * 191 UNITS = 22,920 GPD
 - PEAK FLOW: 22,920 GPD * (250 GPD/AC * 11.74 AC) + (0.003 * 3.59 IN/HR * 11.74 AC * 646,317 GPD/CF5) = 107,575 GPD
 - ANTICIPATED WATER DEMAND:
 - DAILY = 191 UNITS * 125 GPD/PERSON * 2.78 PERSONS/UNIT = 66,373 GPD
 - MAXIMUM DAILY WATER DEMAND = 66,373 GPD * 2.2 = 146,020 GPD
 - PEAK HOUR DEMAND = 2 * 146,020 GPD/3600 MINS/DAY = 81 GPM
 - THERE ARE NO KNOWN DOWNSTREAM SEWER CAPACITY LIMITATIONS.
- A PERMANENT EASEMENT WILL BE GRANTED TO THE CITY OF LEE'S SUMMIT TO LOCATE, CONSTRUCT AND MAINTAIN OR TO AUTHORIZE THE LOCATION, CONSTRUCTION AND MAINTENANCE OF A SIDEWALK FOR PEDESTRIAN ACCESS OVER, ALONG AND ACROSS THE STRIPS OF LAND DESIGNATED AS "SIDEWALK EASEMENT" OR BY THE ABBREVIATION "S/E" ON THE ACCOMPANYING PLAT.
- SITE SHALL BE DESIGNED IN ACCORDANCE WITH THE 2018 INTERNATIONAL FIRE CODE
- DUMPSTER ENCLOSURE GATES SHALL HAVE OPAQUE, METAL PANEL MATERIAL MOUNTED ON THE GATE FRAME TO PROVIDE SCREENING.

V:\192.168.0.99\Projects\General\Projects\16803-SWD-Lees-Summit-Senior-CDs\CAD\16803 PRE PLAT.dwg
 Feb 09 2026 3:13pm

\\192.168.0.99\Projects\General Projects\16803-SWD-Lees-Summit-Senior-CDs\CAD\16803 PRE PLAT.dwg
Jan 26, 2026 5:28pm

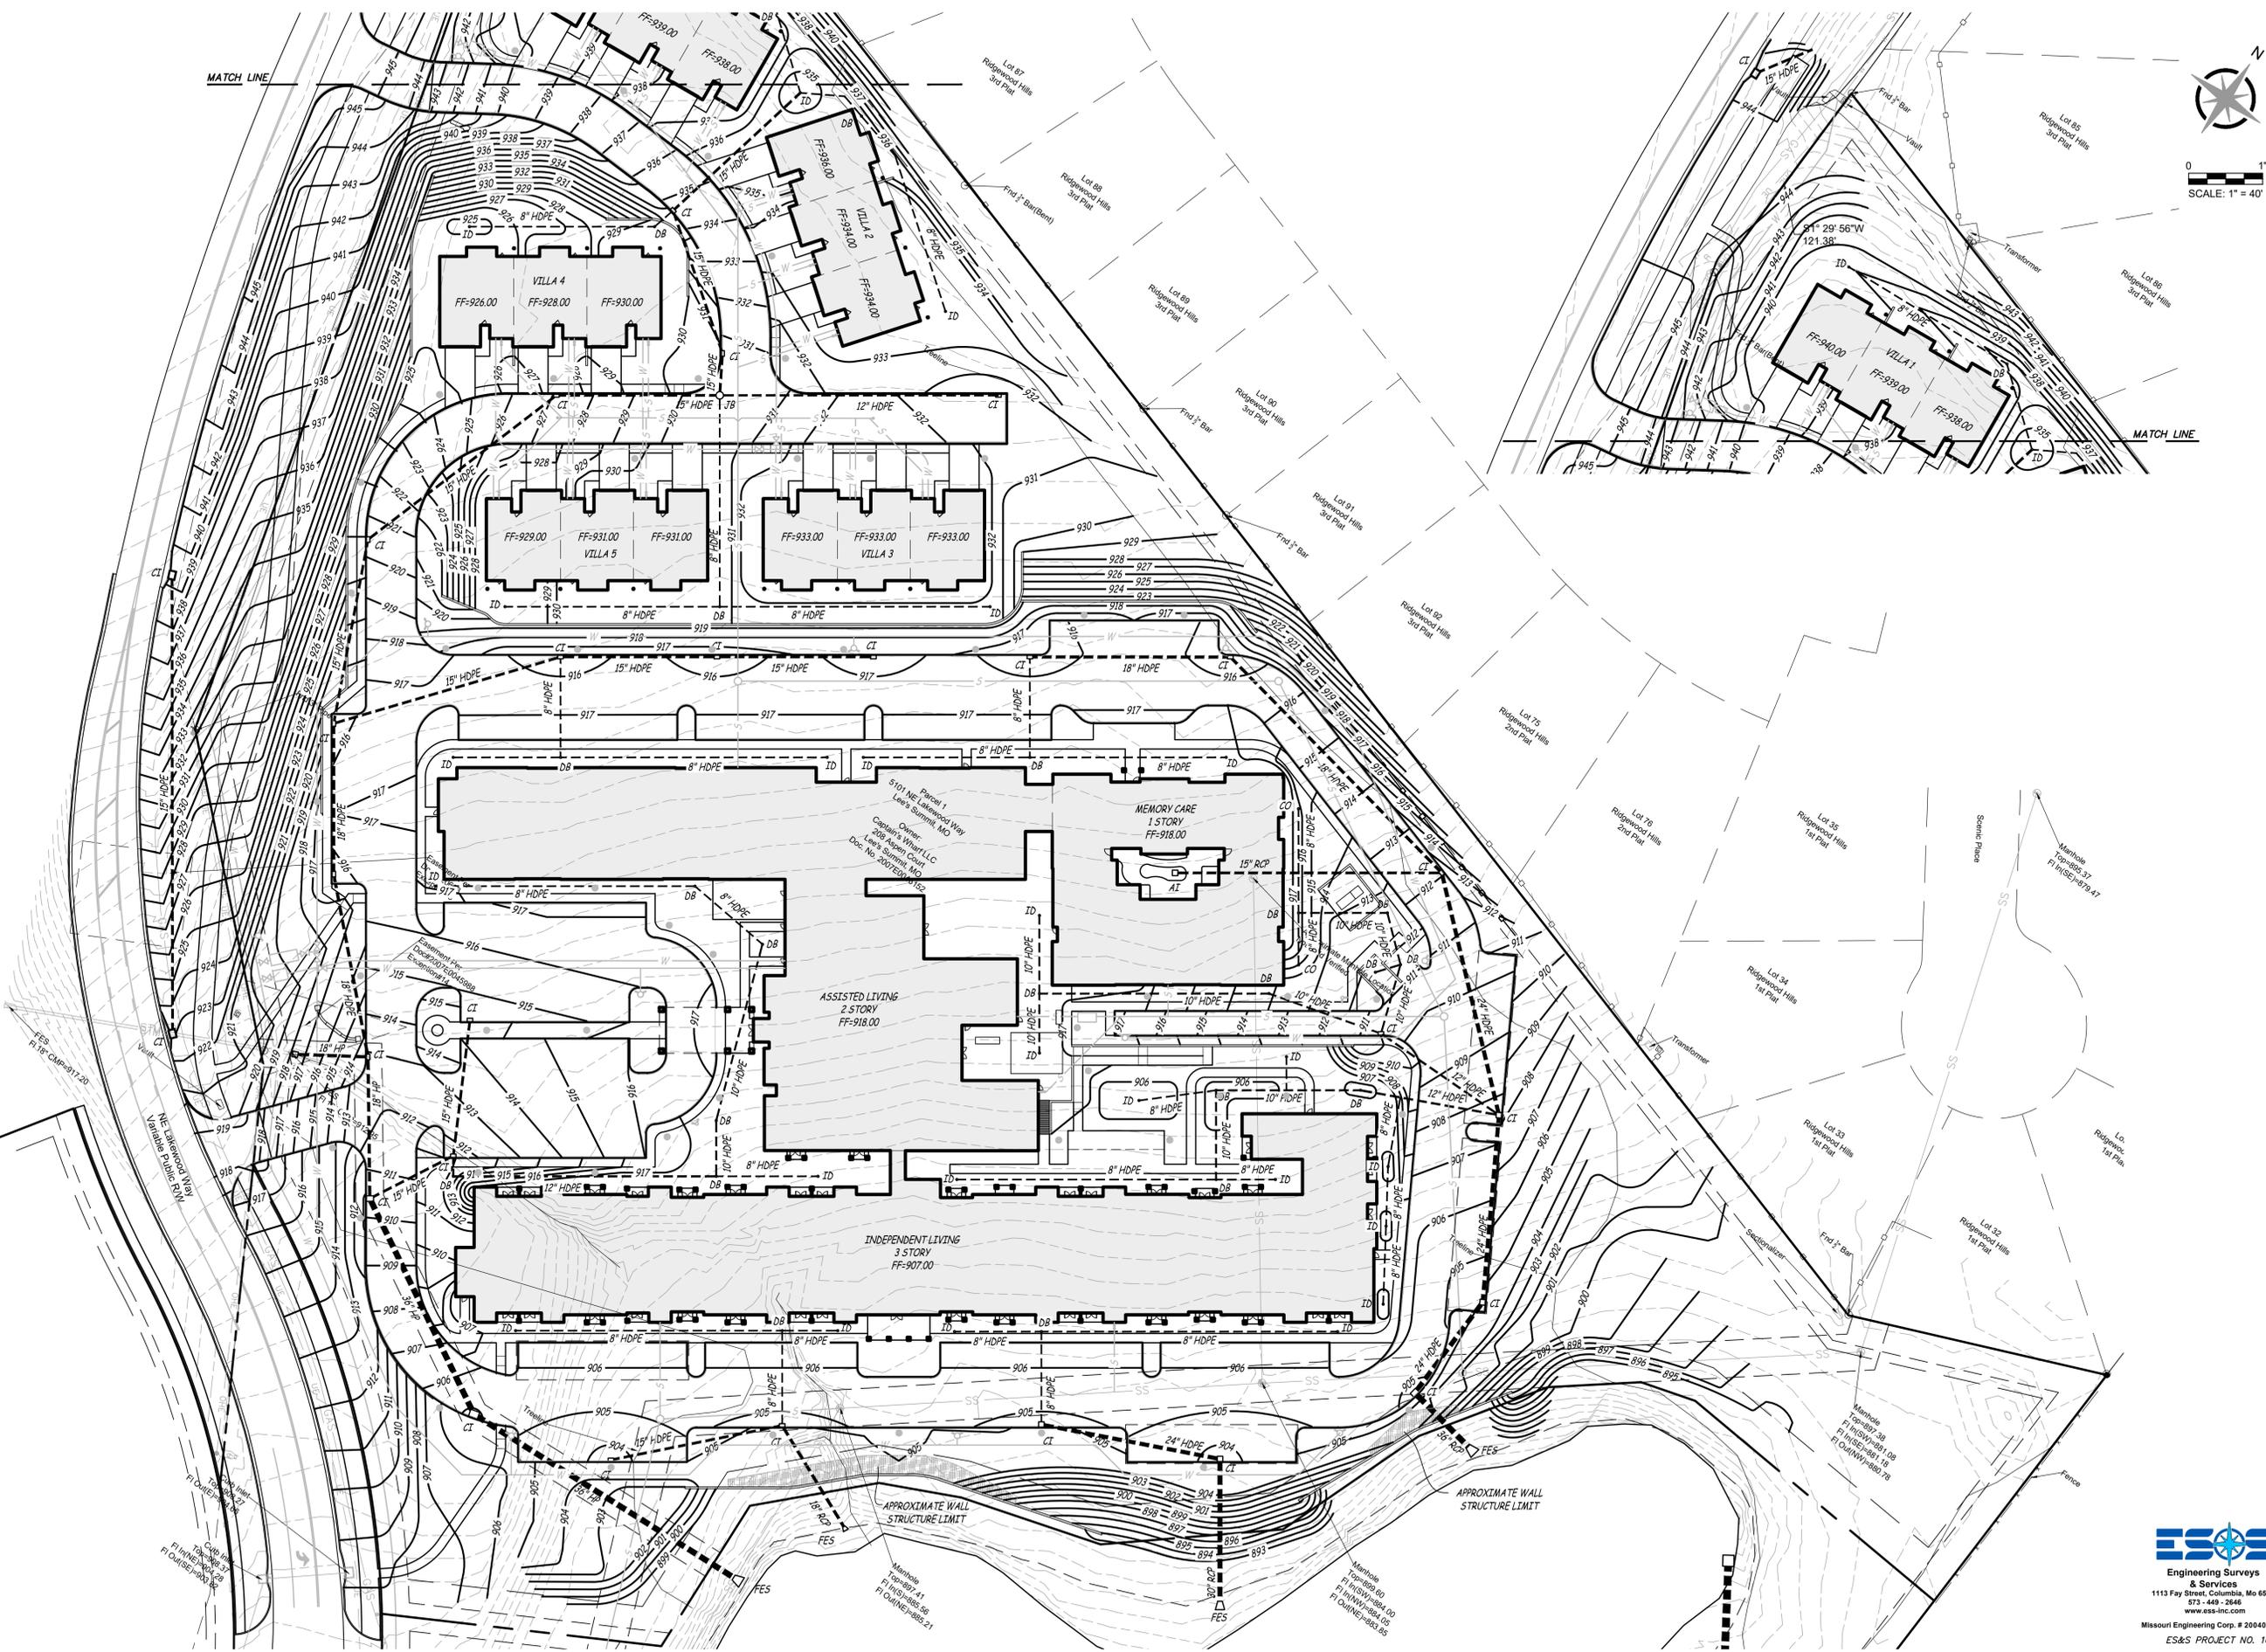

ARCHITECTURAL CORPORATION
MISSOURI CERTIFICATE
OF AUTHORITY NO. 000073

LEE'S SUMMIT SENIOR COMMUNITY
5101 NE LAKEWOOD WAY
LEES SUMMIT, JACKSON COUNTY, MISSOURI 64064

STARK WILSON DUNCAN ARCHITECTS INC
315 NICHOLS RD. STE 228 - KANSAS CITY, MO 64112 - T 816.531.1698 - WWW.SWDARCHITECTS.COM




PRELIMINARY
DEVELOPMENT PLAN &
SPECIAL USE PERMIT
GRADING PLAN

ISSUE DATE:
12.22.2025
REVISIONS:
REVISION - 01/26/2026



PROJECT NO.: 2510
C2.02
© 2025 SWD ARCHITECTS INC.


\\192.168.0.99\Projects\General Projects\16803-SWD-Lees-Summit-Senior-CAD\16803 PRE PLAT.dwg
 Jan 26, 2026 5:22pm

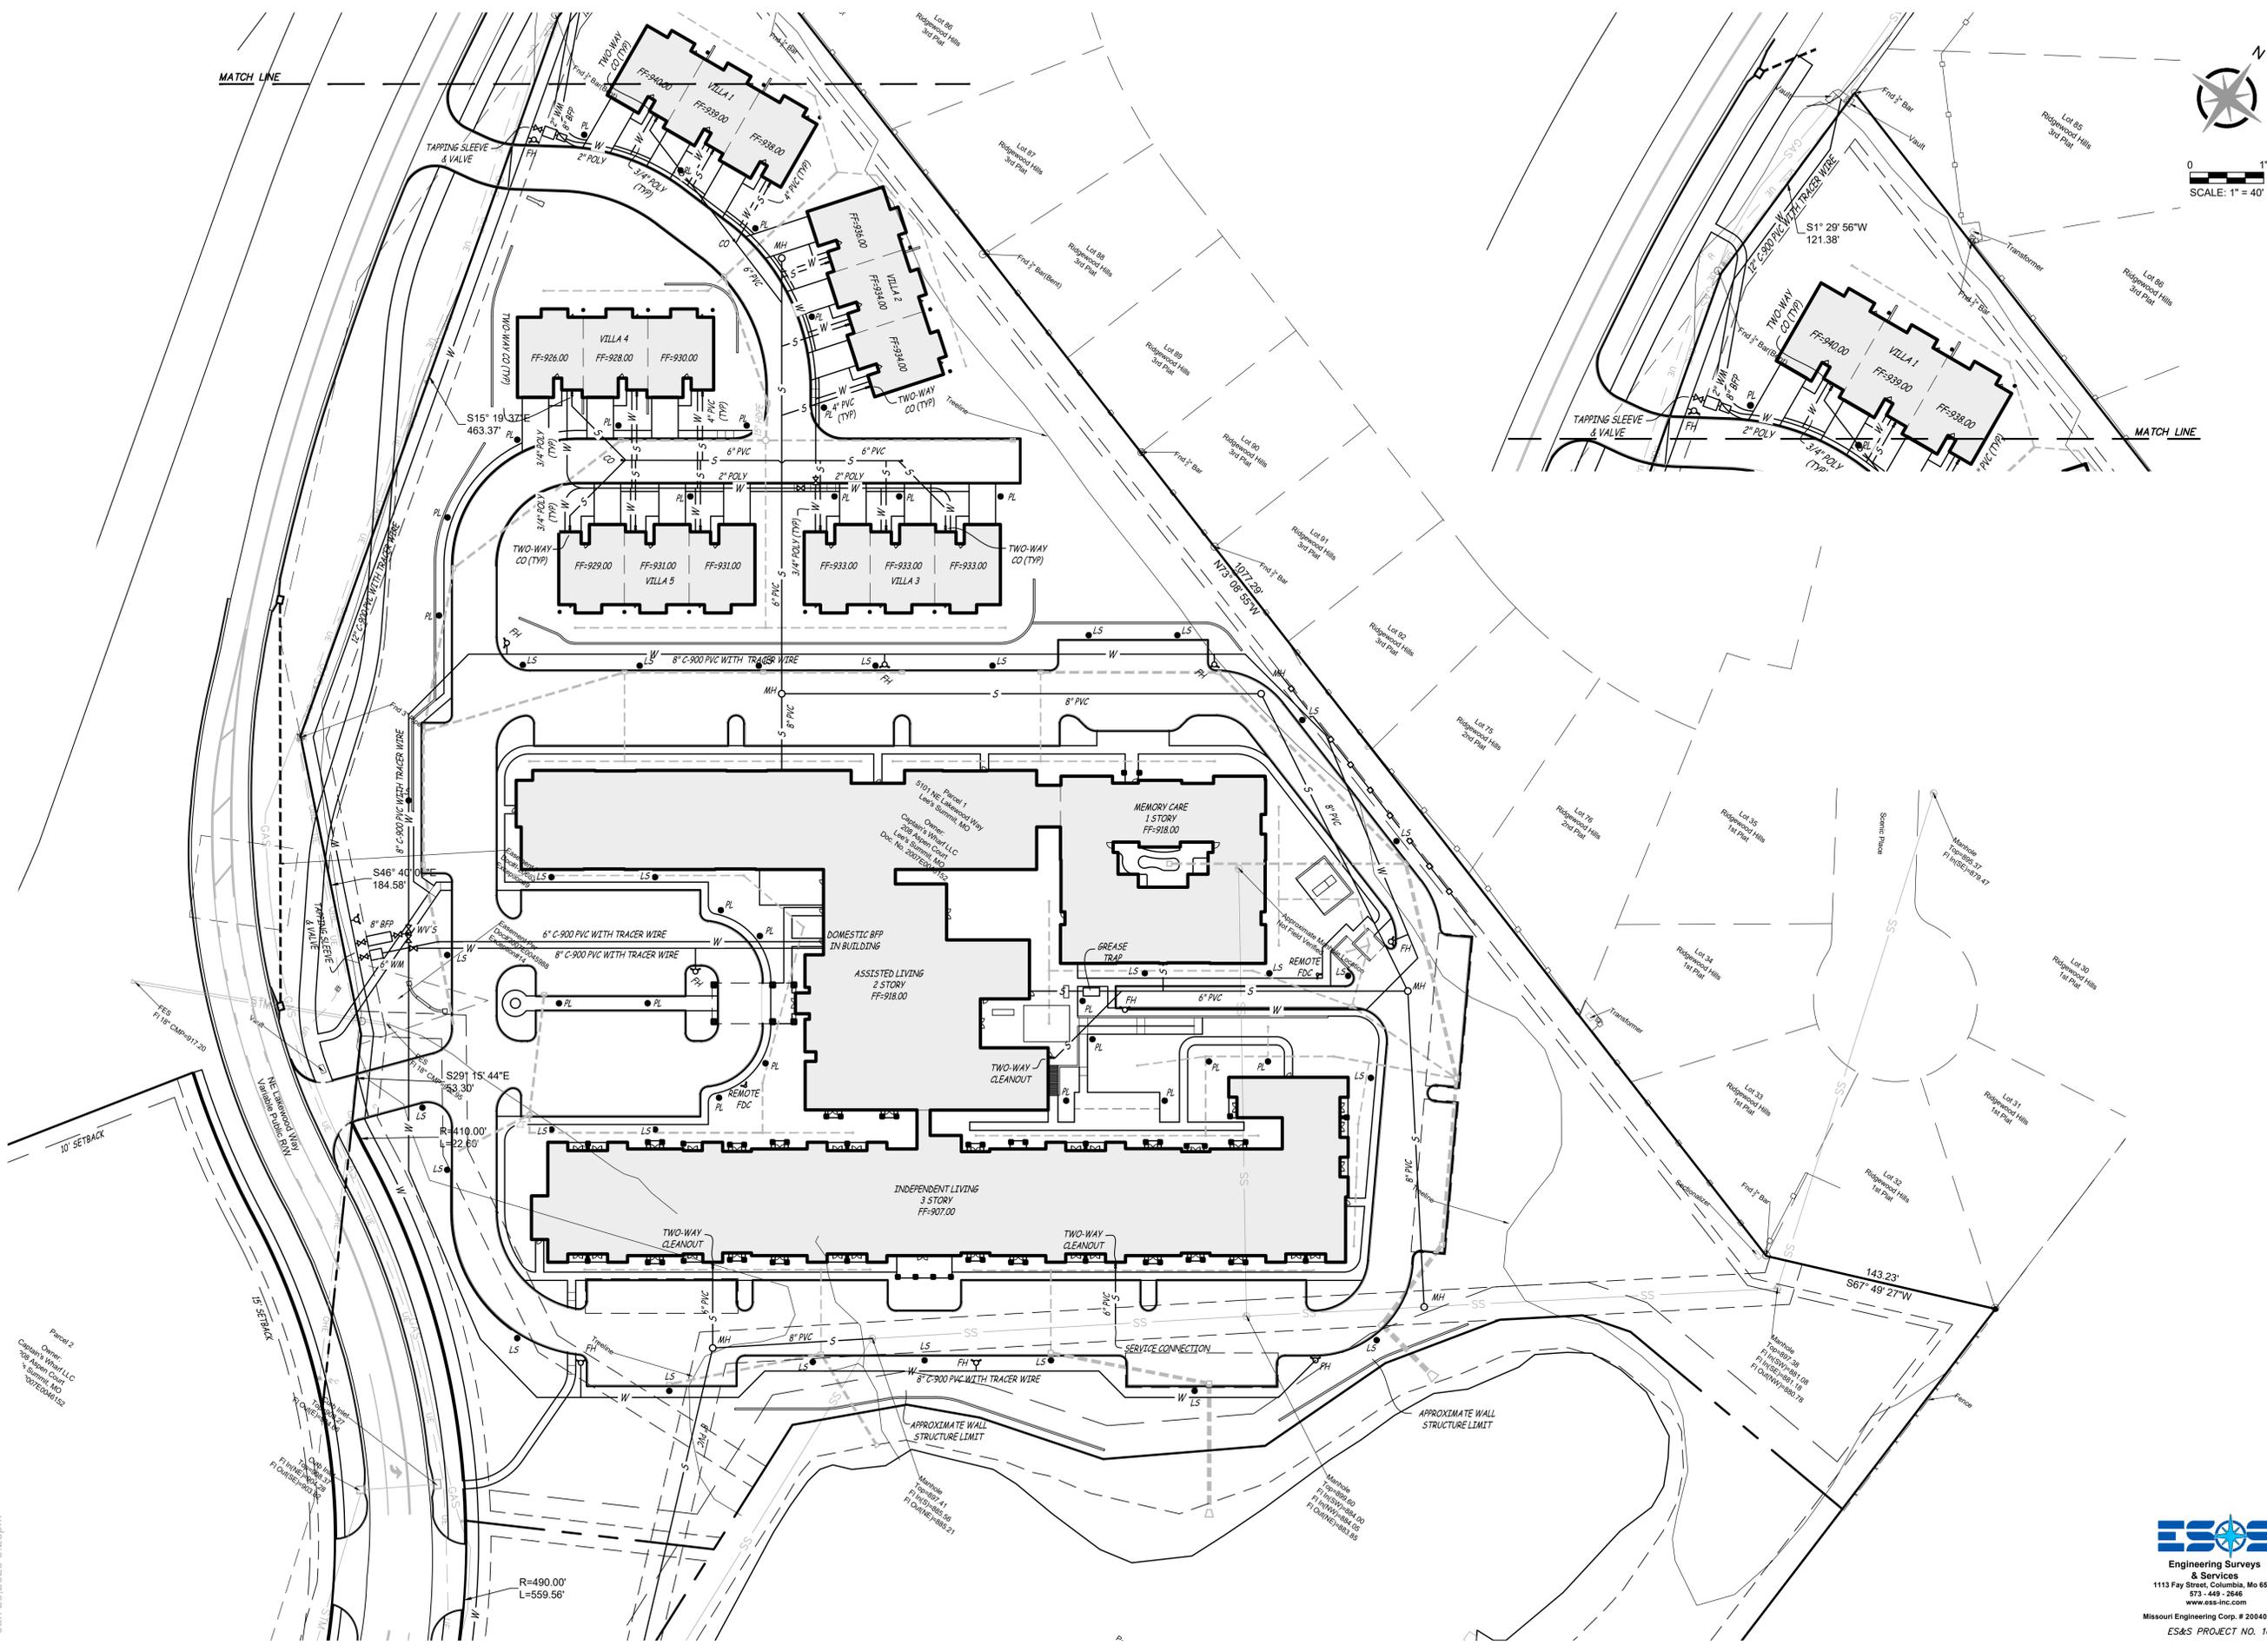

ARCHITECTURAL CORPORATION
 MISSOURI CERTIFICATE
 OF AUTHORITY NO. 000073

LEE'S SUMMIT SENIOR COMMUNITY
 5101 NE LAKEWOOD WAY
 LEE'S SUMMIT, JACKSON COUNTY, MISSOURI 64064

STARK WILSON DUNCAN ARCHITECTS INC
 315 NICHOLS RD. STE 228 - KANSAS CITY, MO 64112 - T 816.531.1699 - WWW.SWDARCHITECTS.COM


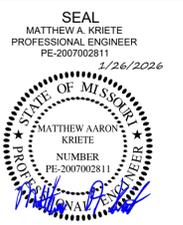


PRELIMINARY
 DEVELOPMENT PLAN &
 SPECIAL USE PERMIT
 UTILITY PLAN

ISSUE DATE:
 12.22.2025
 REVISIONS:
 REVISION - 01/26/2026




PROJECT NO.: 2510
C2.03
 COPYRIGHT © 2025 SWD ARCHITECTS INC.

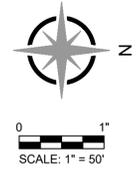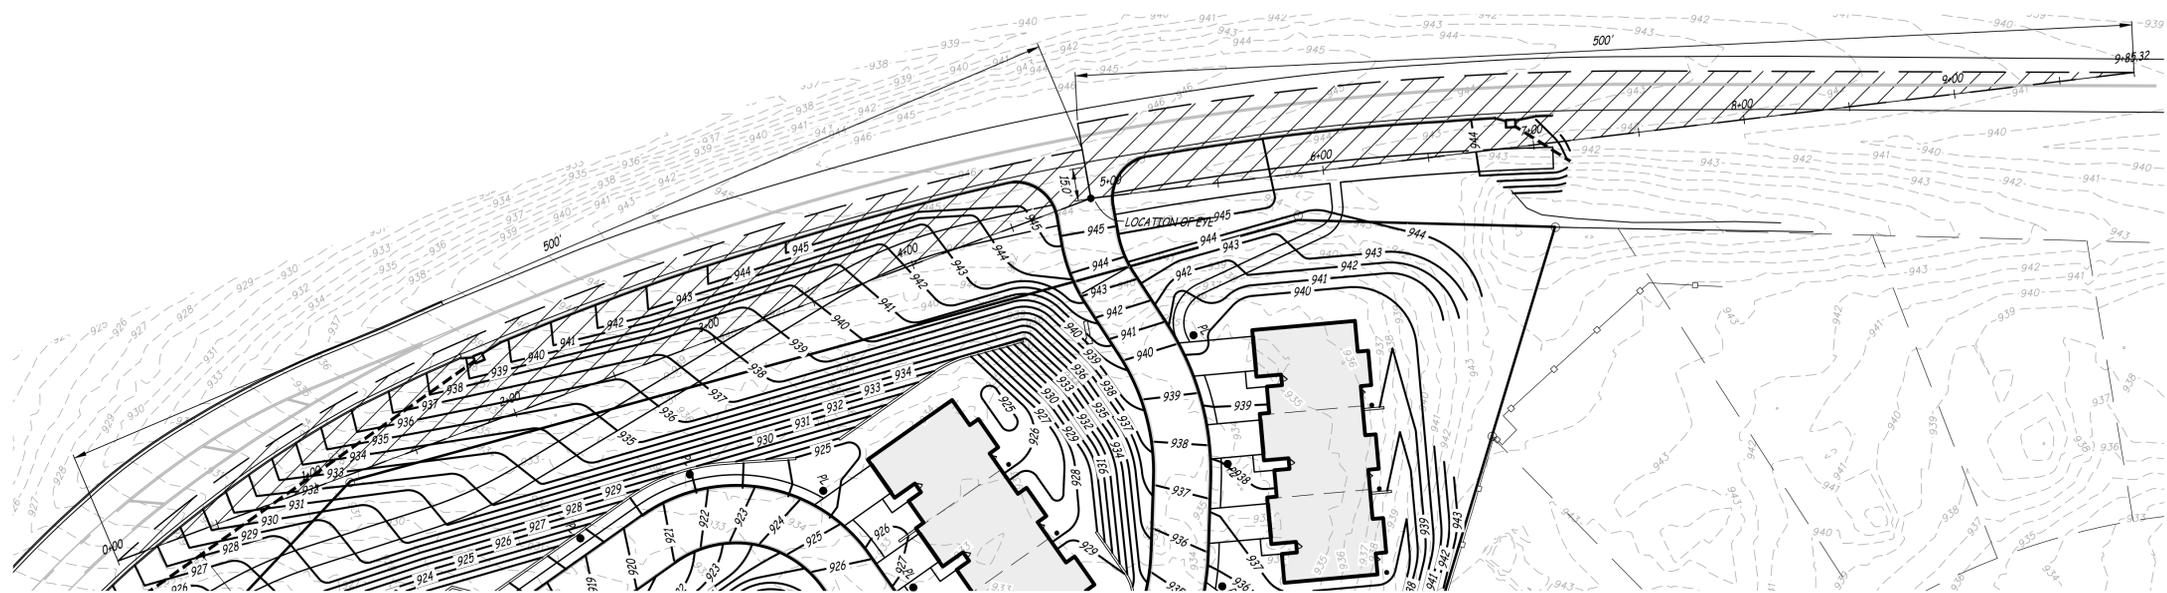



ARCHITECTURAL CORPORATION
MISSOURI CERTIFICATE
OF AUTHORITY NO. 000073

LEE'S SUMMIT SENIOR COMMUNITY
5101 NE LAKEWOOD WAY
LEE'S SUMMIT, JACKSON COUNTY, MISSOURI 64064

STARK WILSON DUNCAN ARCHITECTS INC
315 NICHOLS RD. STE 228 - KANSAS CITY, MO 64112 - T 816.531.1696 - WWW.SWDARCHITECTS.COM

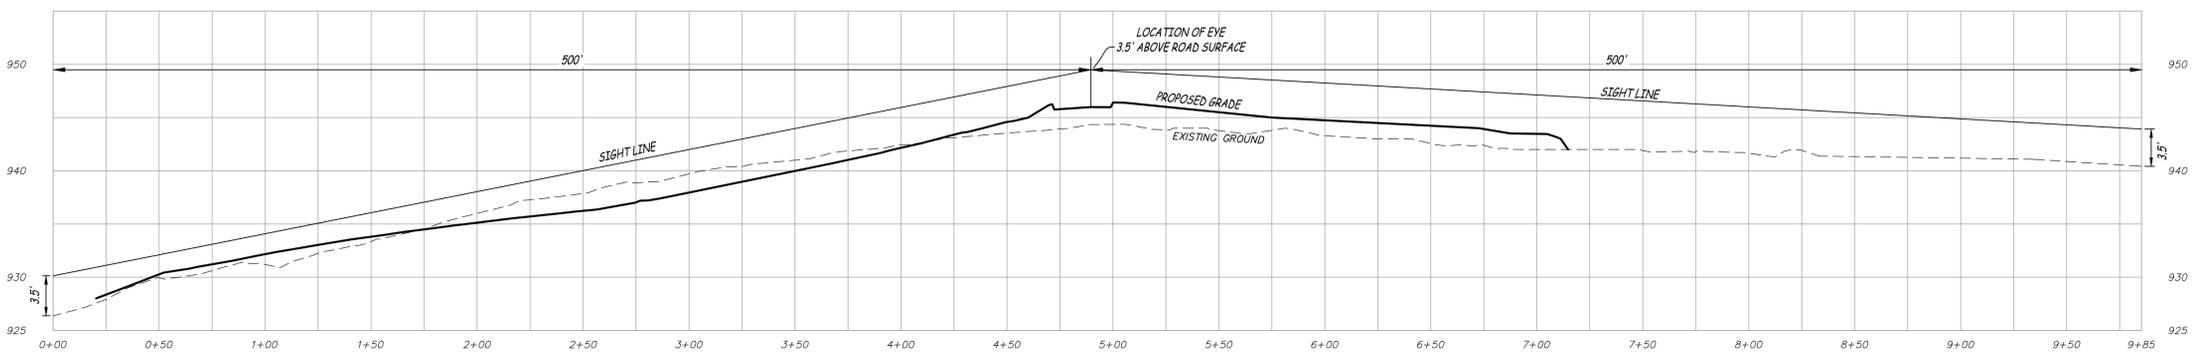

NORTH SIGHT DISTANCE
SCALE - HORIZ. 1" = 50'
VERT. 1" = 10'

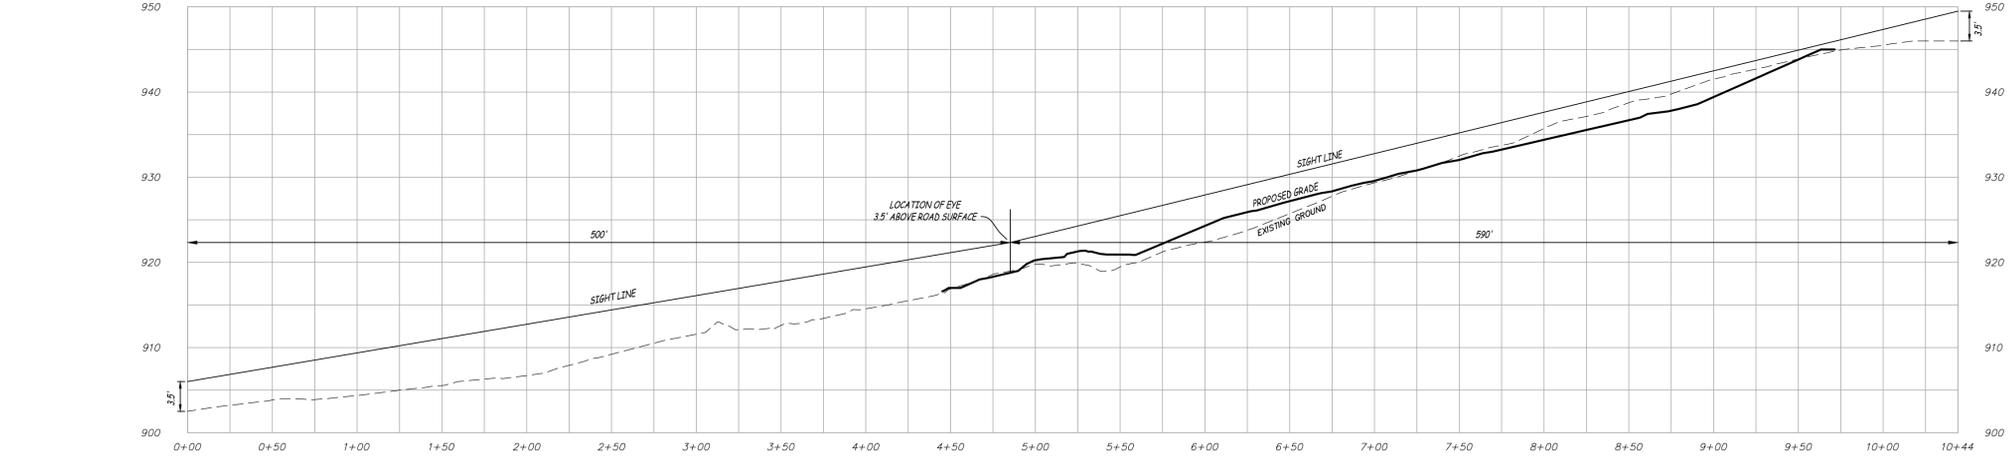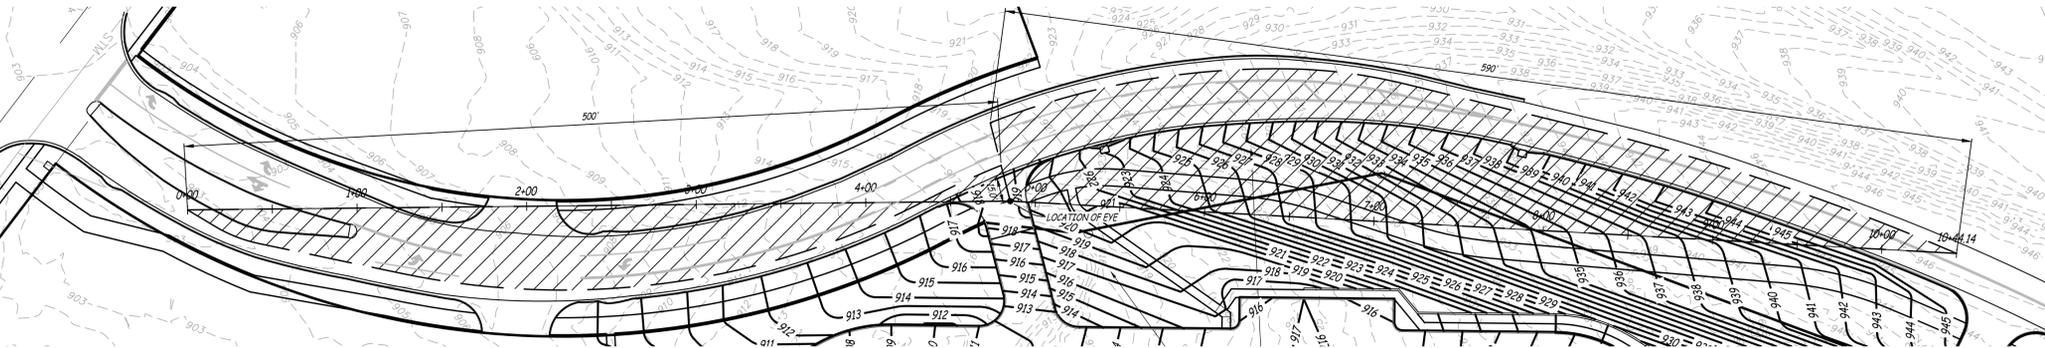

SOUTH SIGHT DISTANCE
SCALE - HORIZ. 1" = 50'
VERT. 1" = 10'

SITE DISTANCE NOTE

1. THE CONSTRUCTED PRODUCT WILL PROVIDE THE INTERSECTION SIGHT DISTANCE AS PROPOSED ON PLAN, AND FIELD VERIFICATION WILL BE CONDUCTED AND RESULTS PROVIDED TO THE COUNTY PRIOR TO FINAL SITE ACCEPTANCE.
2. HIGHWAY 76 SPEED LIMIT = 45 MPH
3. REQUIRED SOUTH DRIVEWAY RIGHT SIGHT DISTANCE = $1.47 \times 45 \text{ MPH} \times (6.5 + (0.1 \times 4\%)) = 456 \text{ FEET DESIGN (SHOWN AS 500 FEET)}$
4. REQUIRED SOUTH DRIVEWAY LEFT SIGHT DISTANCE = $1.47 \times 45 \text{ MPH} \times (7.5 + (0.2 \times 7\%)) = 589 \text{ FEET DESIGN (SHOWN AS 590 FEET)}$
5. REQUIRED NORTH DRIVEWAY RIGHT SIGHT DISTANCE = $1.47 \times 45 \text{ MPH} \times 6.5 = 430 \text{ FEET DESIGN (SHOWN AS 500 FEET)}$
6. REQUIRED NORTH DRIVEWAY LEFT SIGHT DISTANCE = $1.47 \times 45 \text{ MPH} \times 7.5 = 496 \text{ FEET DESIGN (SHOWN AS 500 FEET)}$
7. EYE HEIGHT = 3.5'
8. OBJECT HEIGHT = 3.5'

SEAL
MATTHEW A. KRLETE
PROFESSIONAL ENGINEER
PE-2007002811
1/26/2026

Matthew A. Krlete

SIGHT DISTANCE EXHIBIT


ISSUE DATE:
12.22.2025

REVISIONS:
① REVISION - 01/26/2026
② REVISION - 02/09/2026



PROJECT NO.: 2510
C3.01
MISSOURI ENGINEERING CORP. # 2004005018
ES&S PROJECT NO. 16803
COPYRIGHT © 2025 SWD ARCHITECTS INC.

\\192.168.0.99\Projects\General Projects\16803-SWD-Lees-Summit-Senior-CAD\16803 PRE PLAT.dwg
Feb 09, 2026 3:14pm

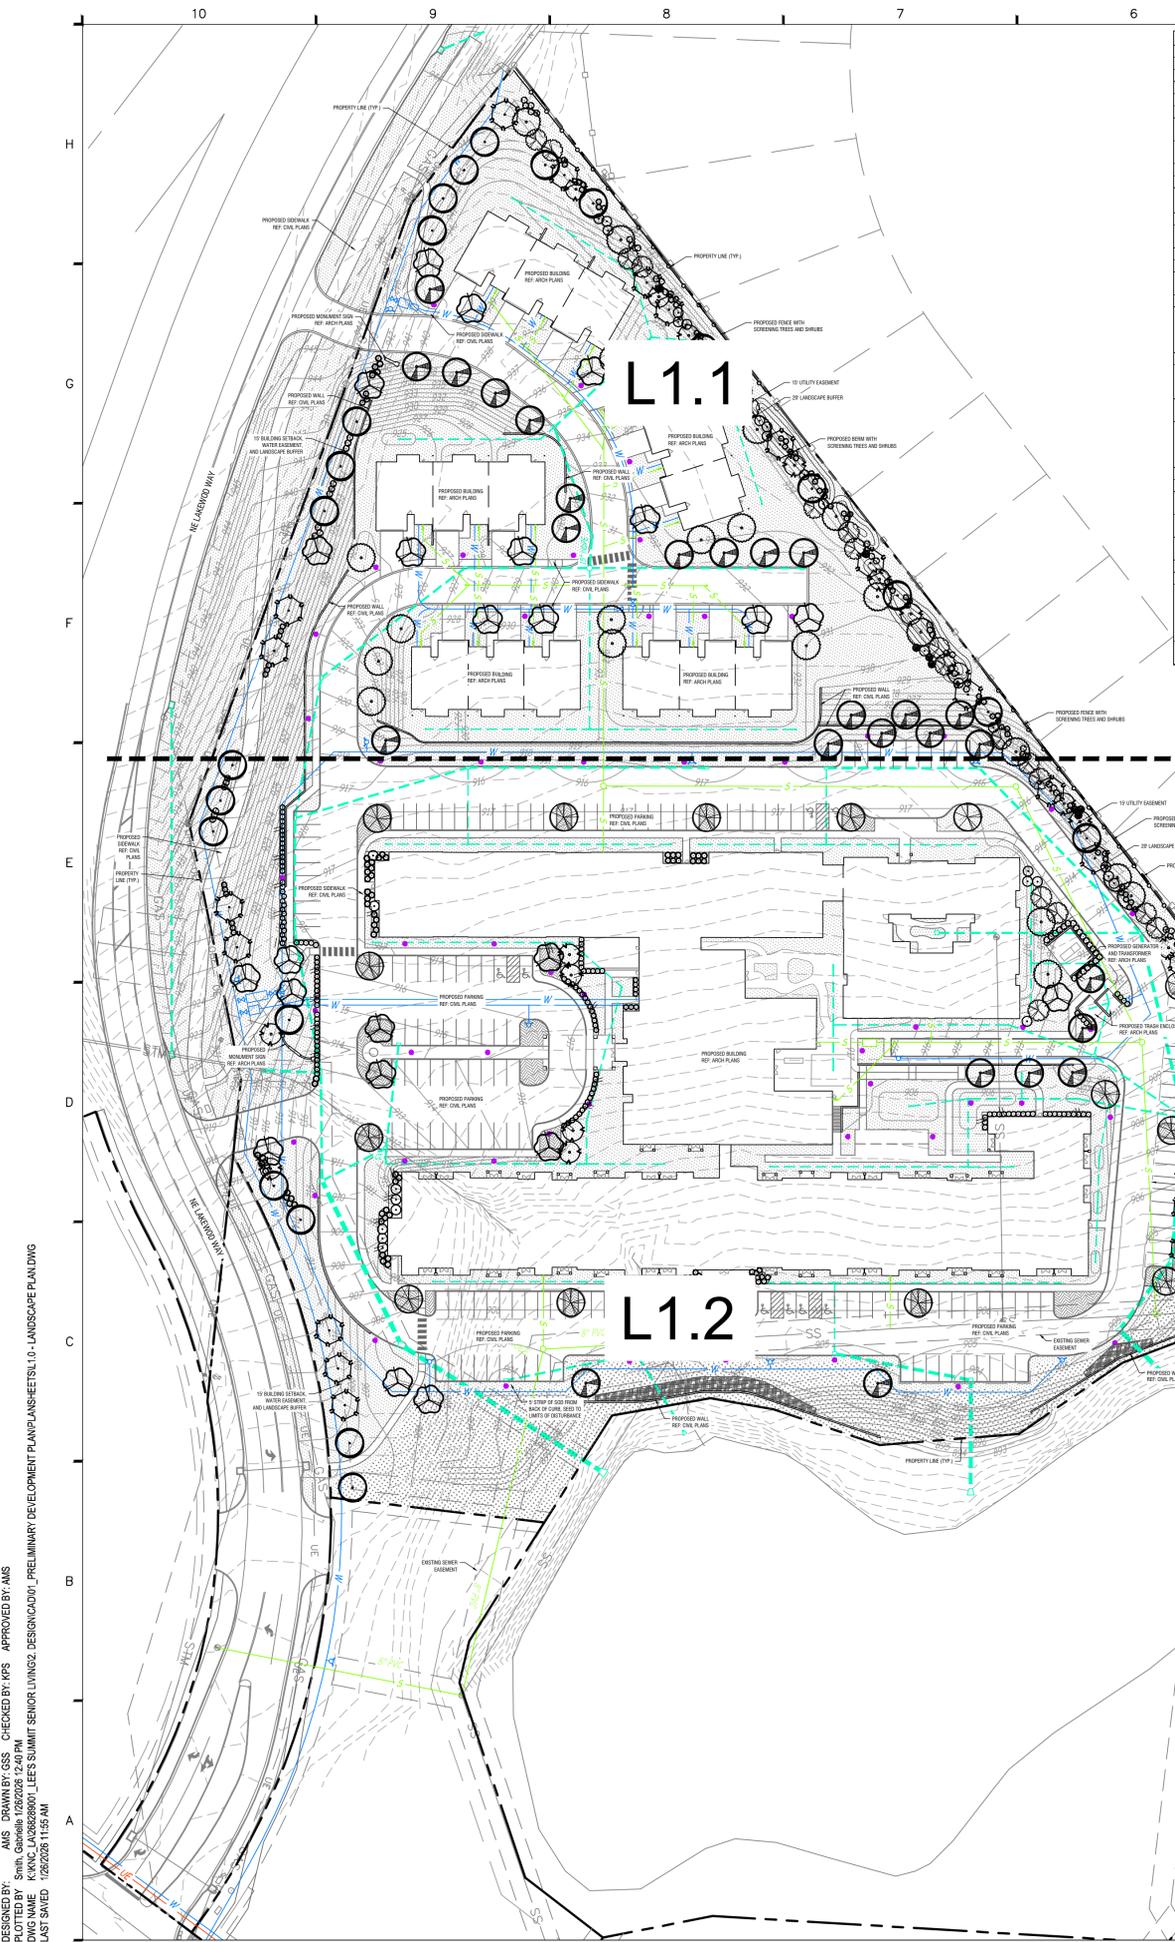

Lee's Summit, Missouri - Landscape Data Table
Site Area: 11.94 acres (519,988 SF) - Zoning (CP-2)


	REQUIRED	PROVIDED
Section 8.750 - Landscape Minimum Requirements		
A. Street Frontage		
One tree shall be planted for each 30 feet of street frontage (public or private) within the landscape setback	Yes	Yes
NE Lakewood Way - 689 LF / 30' = 23 Trees	NE Lakewood Way - 30 Trees	NE Lakewood Way - 30 Trees
A minimum of 20 feet wide landscape strip shall be provided along the full length of any street frontage, except where the building setback is less than 20 feet	Yes	Yes - 15 Building Setback
One shrub shall be provided for every 20 feet of street frontage within the landscape setback abutting street frontage.	Yes	Yes
NE Lakewood Way - 689 LF / 20' = 45 Shrubs	NE Lakewood Way - 45 Shrubs	NE Lakewood Way - 45 Shrubs
B. Open Yard Areas		
The minimum open yard area landscaping requirements shall be two shrubs per 5,000 SF of total lot area (excluding building footprint area)	163 Shrubs	163 Shrubs
220,024 SF Lot Area - 111,548 SF Building Footprint = 405,944 SF / 5,000 SF = 81.188 Shrubs		
In addition to the trees required based on street frontage, additional trees shall be required at a ratio of one tree for every 5,000 SF of lot area not covered by buildings/structures.	82 Trees	82 Trees
220,024 SF Lot Area - 111,548 SF Building Footprint = 405,944 SF / 5,000 SF = 81.188 Trees		
Section 8.810 - Parking Lot Landscaping and Trees		
Landscape islands, strips or other planting areas shall be located within the parking lot and constitute at least five percent of the entire area devoted to parking spaces, aisles and driveways.	3,027 SF	3,027 SF
60,526 SF Parking Lot Area / 20.05' = 3,027 SF		
A landscape island shall be located at the end of every parking bay between the last parking space and an adjacent travel aisle or driveway. The island shall be no less than one foot wide for at least one-half the length of the adjacent parking space. The island shall be planted in trees, shrubs, grass, or groundcover, except for those areas that are mulched.	Yes	Yes
Section 8.820 - Screening, Parking Lot		
For any parking lot designed or intended to accommodate five cars or more and any area set aside for loading or unloading of trucks or vans, if such parking lot or loading area is visible from a street right of way, a visual screen shall be provided as required below.		
Screening to a height of two and one-half feet must be provided along the edge of parking lot or loading area (closest to and parallel to the street). A driveway to the parking lot or loading area may interrupt the screening.	Yes	Yes
Planting only screening a hedge consisting of at least 12 shrubs per 40 linear feet that will spread into a continuous visual screen within two growing seasons. Shrubs must be at least 18 inches tall at the time of planting and be of a species that will normally grow to at least two and one-half feet in height at maturity and be suitable for the parking lot application.		
Section 8.870 - Buffer/Screens Required Between Land Uses		
Buffer/screens between developments of differing land uses adjoining one another or separated from one another by only a street or alley shall comply with Table 8.890, Typical Buffers.		
Size of the Buffer/Screens required along any side lot line shall be no less than 20 feet or as approved by the governing body.	Yes	Yes
Rear lot line. Buffer/Screens along any rear lot line shall be no less than 20 feet or as approved by the governing body.		
8' x 4' Adjoining Use x CP-2 Proposed Use - High Impact Buffer/Screen for 911.8 ft		
3' High Beam	3' High Beam	3' High Beam
Section C: Low Impact Screen C:		
1 Shade Tree / 250 sf - 31 Shade Trees	31 Shade Trees	31 Shade Trees
1 Ornamental Tree / 250 sf - 31 Ornamental Trees	31 Ornamental Trees	31 Ornamental Trees
1 Evergreen Tree / 750 sf - 32 Evergreen Trees	31 Evergreen Trees	31 Evergreen Trees
1 Shrub / 200 sf - 120 Shrubs	114 Shrubs	114 Shrubs
Notes: 33 & 32 have requested no screening materials adjacent to their property line. The linear footage of those lots have been removed from this calculation.		

- PLANTING NOTES:**
- REFER TO LANDSCAPE SPECIFICATIONS FOR REQUIRED SUBMITTALS.
 - CONTRACTOR SHALL SOD TO LIMITS OF DISTURBANCE.
 - ALL PLANT MATERIAL SHALL BE INSTALLED ACCORDING TO SOUND NURSERY PRACTICES AND SHALL MEET ALL STANDARDS AS STATED IN THE LATEST EDITION OF "AMERICAN STANDARD FOR NURSERY STOCK" BY THE AMERICAN ASSOCIATION OF NURSERYMEN.
 - NO SUBSTITUTIONS IN PLANT MATERIALS SHALL BE MADE WITHOUT WRITTEN AUTHORIZATION FROM OWNER OR LANDSCAPE ARCHITECT. IN THE EVENT OF DISCREPANCIES BETWEEN DRAWING AND PLANT LIST, THE DRAWING SHALL PREVAIL.
 - LOCATE ALL UTILITIES PRIOR TO ANY AND ALL PLANTING OR DIGGING OPERATIONS. HAND DIG TREES AND SHRUBS IN AREAS WITHIN 5' OF UTILITIES. CONTRACTOR SHALL BE RESPONSIBLE FOR ALL DAMAGES TO EXISTING UTILITIES INCURRED BY HIS WORK.
 - TREE STAKING: REFER TO TYPICAL TREE PLANTING DETAIL FOR TREE STAKING. CONTRACTOR SHALL REPLACE, PLANT, OR UPRIGHT ANY TREES BLOWN OVER OR DAMAGED DUE TO INADEQUATE STAKING AT NO ADDITIONAL COST TO OWNER.
 - PLANTS MASSSED IN BEDS SHALL BE ARRANGED USING TRIANGULAR SPACING.
 - PROVIDE A LANDSCAPE EDGE BETWEEN ALL PLANTING BEDS AND LAWN AREAS—REFERENCE LANDSCAPE PLAN.
 - ALL PLANTING BEDS TO BE TOP DRESSED WITH A MINIMUM OF 4" SHREDDED HARDWOOD MULCH—REFERENCE LANDSCAPE PLAN.
 - LAY TALL FESCUE SOD FOR PROPOSED LAWN AREAS TO ALL EDGES OF PAVEMENT AND/OR LIMITS SPECIFIED IN LANDSCAPE PLAN. ALL DISTURBED AREAS WITHIN CITY R.O.W. SHALL RECEIVE TALL FESCUE SOD.
 - THE CONTRACTOR SHALL BE RESPONSIBLE FOR THE MAINTENANCE OF ALL LANDSCAPING UNTIL FINAL ACCEPTANCE. ALL REQUIRED LANDSCAPING SHALL BE MAINTAINED IN A NEAT AND ORDERLY MANNER AT ALL TIMES. THE WORK SHALL INCLUDE, BUT NOT TO BE LIMITED TO, MOWING, EDGING, PRUNING, FERTILIZING, WATERING, WEEDING, AND OTHER SUCH ACTIVITIES COMMON TO THE MAINTENANCE OF LANDSCAPING. ALL PLANT MATERIALS SHALL BE MAINTAINED IN A HEALTHY AND GROWING CONDITION AS IS APPROPRIATE FOR THE SEASON OF THE YEAR. PLANT MATERIAL THAT DIES SHALL BE REPLACED WITH PLANT MATERIAL OF SIMILAR SIZE AND VARIETY.
 - CONTRACTOR SHALL WARRANTY PLANT MATERIAL TO REMAIN ALIVE AND HEALTHY FOR A PERIOD OF ONE YEAR AFTER FINAL ACCEPTANCE. WARRANTY SHALL NOT INCLUDE DAMAGE FOR LOSS OF PLANT MATERIAL DUE TO ACTS OF VANDALISM OR NEGLIGENCE ON THE PART OF OWNER.
 - ALL LANDSCAPE BED AREAS TO BE PREPARED USING "ORGANICALLY ENRICHED TOP SOIL" BY MISSOURI ORGANIC (OR APPROVED EQUIVALENT). INSTALL TO DEPTHS PER LANDSCAPE DETAILS (12" DEPTH MIN.). FINISHED GRADES OF LANDSCAPE BEDS TO BE 2" BELOW FINISHED GRADE OF ADJACENT PAVING OR AS SHOWN ON GRADING PLAN. CONTRACTOR TO SUBMIT 1 GALLON SAMPLE (MIN.) TO THE LANDSCAPE ARCHITECT FOR APPROVAL PRIOR TO PURCHASE.
 - ALL SOD AREAS SHALL RECEIVE 4" DEPTH (MIN.) TOPSOIL PRIOR TO INSTALLATION. TOPSOIL SHALL BE NATURAL, FRIABLE, AND FERTILE; POSSES A pH RANGE OF 7.0-7.5; AND BE FREE OF TRASH, DEBRIS, INSECTS, STONES, WEEDS, AND TWIGS/BRANCHES. CONTRACTOR TO SUBMIT 1 GALLON SAMPLE (MIN.) TO THE LANDSCAPE ARCHITECT FOR APPROVAL PRIOR TO PURCHASE.
 - FERTILIZER: FERTILIZE SEEDED AREAS WITH AN APPROVED COMMERCIAL TYPE, SLOW RELEASE, AT A RATE OF 400 LBS/ACRE. FERTILIZE SODD AREAS WITH THE SAME FERTILIZER TYPE AT A RATE OF 200 LBS/ACRE. REFER TO LANDSCAPE SPECIFICATIONS SECTION G FOR REQUIRED SUBMITTALS. USE PHOSPHOROUS-FREE FERTILIZER IF REQUIRED BY LOCAL CODE.

PLANT SCHEDULE

NOTE: PLANT QUANTITIES ARE PROVIDED FOR CONVENIENCE ONLY. IN THE CASE OF A DISCREPANCY, THE DRAWING SHALL TAKE PRECEDENCE.

SYMBOL	CODE	QTY	BOTANICAL / COMMON NAME	CONT.	CALIPER	SIZE	REMARKS
PARKING LOT TREES							
	AD	14	ACER RUBRUM 'OCTOBER GLORY' / OCTOBER GLORY RED MAPLE	B & B	2.5" CAL. MIN.	12' - 14' HT.	SINGLE, STRAIGHT LEADER, FULL & MATCHING
SHADE TREES							
	AA	24	ACER RUBRUM 'ARMSTRONG' / ARMSTRONG RED MAPLE	B & B	2.5" CAL. MIN.	12' - 14' HT.	SINGLE, STRAIGHT LEADER, FULL & MATCHING
	OO	25	QUERCUS X BIMUNDORUM 'CRIMSCHMIDT' / CRIMSON SPIRE™ OAK	B & B	2.5" CAL. MIN.	12' - 14' HT.	SINGLE, STRAIGHT LEADER, FULL & MATCHING
	UD	26	ULMUS AMERICANA 'LEWIS & CLARK' / PRAIRIE EXPEDITION® AMERICAN ELM	B & B	2.5" CAL. MIN.	12' - 14' HT.	SINGLE, STRAIGHT LEADER, FULL & MATCHING
	UP	23	ULMUS PARVIFOLIA / LACEBARK ELM	B & B	2.5" CAL. MIN.	12' - 14' HT.	SINGLE, STRAIGHT LEADER, FULL & MATCHING
	ZM	24	ZELKOVA SERRATA 'MUSASHINO' / MUSASHINO JAPANESE ZELKOVA	B & B	2.5" CAL. MIN.	12' - 14' HT.	SINGLE, STRAIGHT LEADER, FULL & MATCHING
EVERGREEN TREES							
	JB	33	JUNIPERUS CHINENSIS 'BLUE POINT' / BLUE POINT JUNIPER	B & B	N/A	8' HT. MIN.	FULL & MATCHING
	TR	10	THUJA OCCIDENTALIS 'EMERALD GREEN' / EMERALD GREEN ARBORVITAE	B & B	N/A	8' HT. MIN.	FULL & MATCHING
ORNAMENTAL TREES							
	CC	21	CERCIS CANADENSIS / EASTERN REDBUD	B & B	1.5" CAL. MIN.	10' - 12' HT.	SINGLE, STRAIGHT LEADER, FULL & MATCHING
	MS	19	MALUS X 'SPRING SNOW' / SPRING SNOW CRABAPPLE	B & B	1.5" CAL. MIN.	10' - 12' HT.	SINGLE, STRAIGHT LEADER, FULL & MATCHING
SHRUBS							
	BG	30	BUXUS X 'GREEN GEM' / GREEN GEM BOXWOOD	3 GAL. MIN.	2" HT. MIN.	SEE PLAN	FULL & MATCHING
	CG	55	CHAMAECYPARIS PRISIFERA 'GOLDEN MOP' / GOLDEN MOP THREADLEAF SAWARA CYPRESS	3 GAL. MIN.	2" HT. MIN.	SEE PLAN	FULL & MATCHING
	IS	76	ILEX GLABRA 'SHAMROCK' / SHAMROCK INKBERRY HOLLY	3 GAL. MIN.	2" HT. MIN.	48" O.C.	FULL & MATCHING
	JS	54	JUNIPERUS X PFITZERIANA 'SEA GREEN' / SEA GREEN PFITZER JUNIPER	3 GAL. MIN.	2" HT. MIN.	84" O.C.	FULL & MATCHING
	TD	103	TAXUS X MEDIA 'DENSIFORMIS' / DENSE ANGLO-JAPANESE YEW	3 GAL. MIN.	2" HT. MIN.	72" O.C.	FULL & MATCHING
	TH	64	THUJA OCCIDENTALIS 'HETZ MIDGET' / HETZ MIDGET ARBORVITAE	3 GAL. MIN.	2" HT. MIN.	SEE PLAN	FULL & MATCHING
GROUND COVERS							
	LV	2,461	LIRIOPE MUSCARI 'VARIEGATA' / VARIEGATED LILYTURF	CONT.	N/A	18" O.C.	FULL & MATCHING
SEED							
	FT	59,509 SF	FESTUCA ARUNDINACEA / TALL FESCUE	SEED	N/A	N/A	SEED TO BE FREE OF WEEDS, PESTS, AND DISEASE
SOD							
	FA	206,037 SF	FESTUCA ARUNDINACEA / TALL FESCUE	SOD	N/A	N/A	SOD TO HAVE TIGHT, SAND-FILLED JOINTS, ROLLED, SOD TO BE FREE OF WEEDS, PESTS, AND DISEASE

 

DESIGNED BY: AMS DRAWN BY: CSS CHECKED BY: KPS APPROVED BY: AMS
 DATE: 12/26/2025 11:55 AM
 DWG NAME: K:\K\12\26\2025\11:55 AM\PRELIMINARY DEVELOPMENT PLANS\REVISIONS\1.0 - LANDSCAPE PLAN.DWG
 LAST SAVED: 12/26/2025 11:55 AM



ARCHITECTURAL CORPORATION
MISSOURI CERTIFICATE
OF AUTHORITY NO. 000073

LEE'S SUMMIT SENIOR COMMUNITY
 5101 NE LAKEWOOD WAY
 LEE'S SUMMIT, JACKSON COUNTY, MISSOURI 64064
 STARK WILSON DUNCAN ARCHITECTS INC.
 315 NICHOLS RD., STE 228 - KANSAS CITY, MO. 64112 - T: 816.551.1898 - WWW.SWDARCHITECTS.COM

SEAL
LANDSCAPE ARCHITECT - ASHLEY SERR
LICENSE NO. PL-A-2024016720



LANDSCAPE PLAN


ISSUE DATE:
1.26.2026
REVISIONS:

PROJECT NO.: 2510

L1.0
COPYRIGHT © 2025 SWD ARCHITECTS INC.

PREPARED BY:
Kimley Horn
 805 PENNSYLVANIA AVENUE, SUITE 150
 KANSAS CITY, MO 64105
 PHONE: 816-652-0350
 WWW.KIMLEY-HORN.COM
 C 2025 KIMLEY-HORN AND ASSOCIATES, INC.
 MO CERTIFICATE OF AUTHORITY # 2012036305,
 EXPIRES 12/31/26

DESIGNED BY: AMS DRAWN BY: CSS CHECKED BY: KPS APPROVED BY: AMS
 DATE: 12/26/2025 11:55 AM
 DWG NAME: K:\K\13\2838001_LEE'S SUMMIT SENIOR LIVING\2. DESIGN\01_PRELIMINARY DEVELOPMENT PLAN\ANSHEETS\L1.0 - LANDSCAPE PLANNING
 LAST SAVED: 12/26/2025 11:55 AM

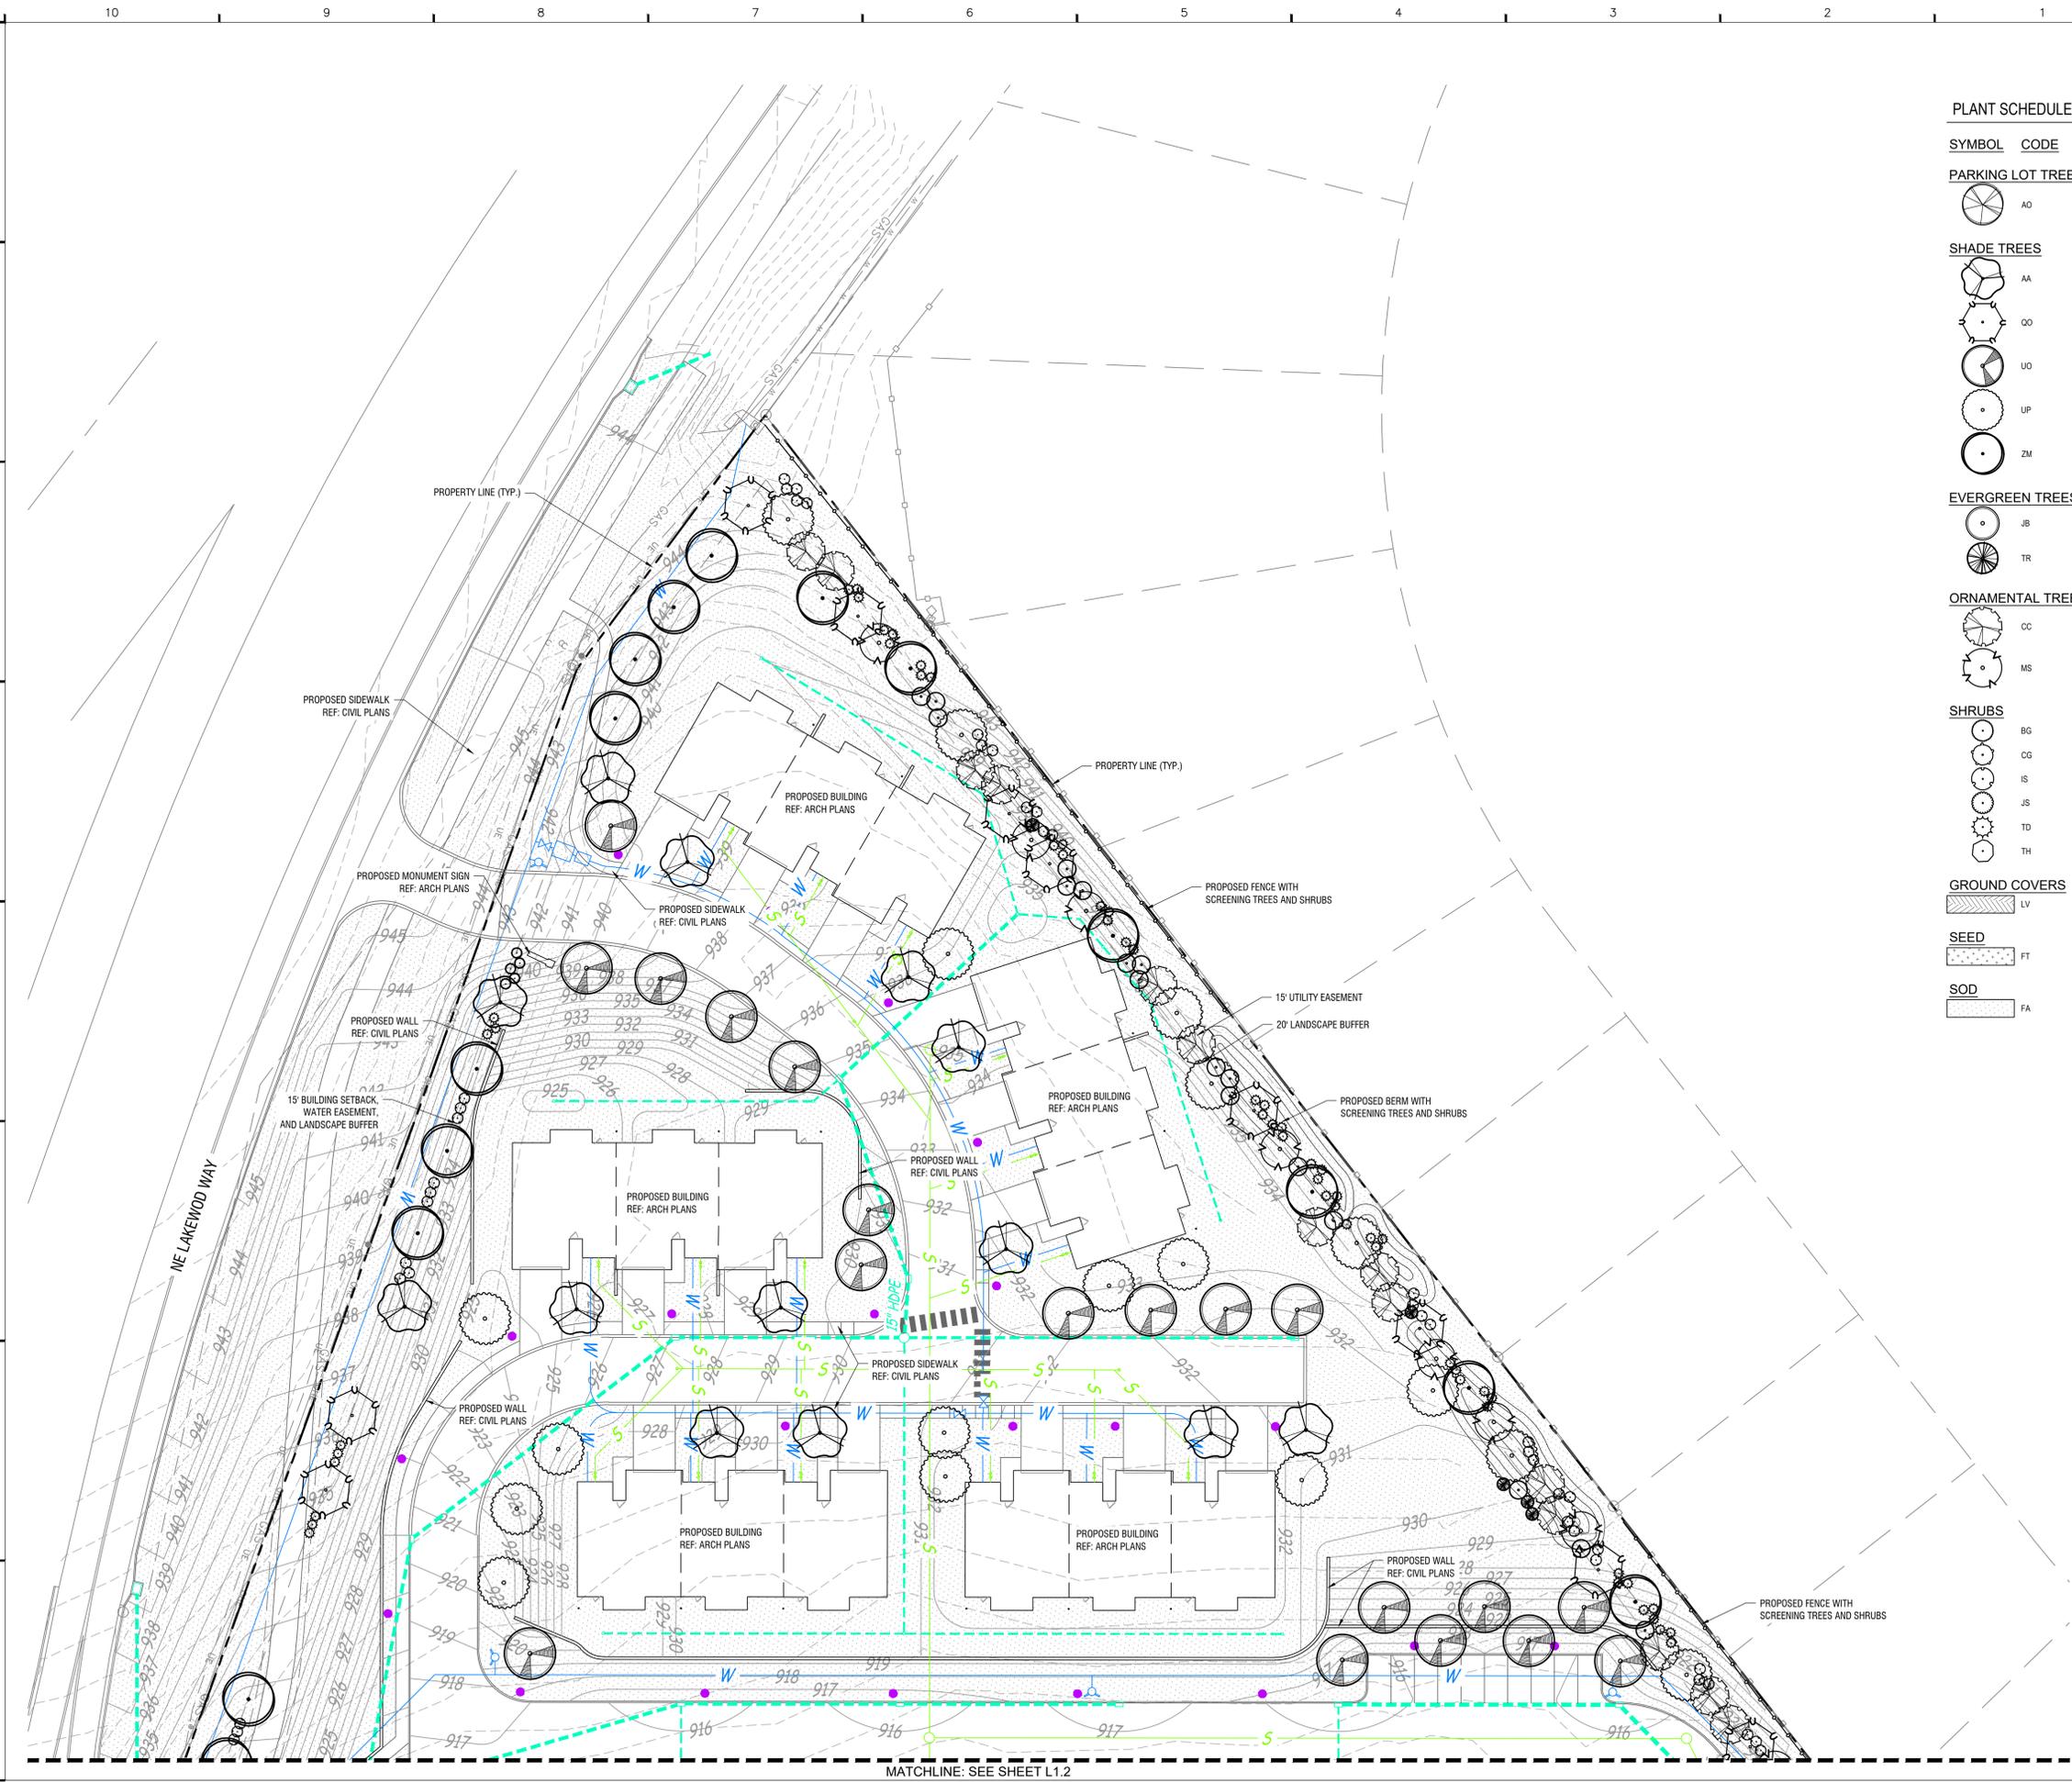

PLANT SCHEDULE NOTE: SEE SHEET L1.0 FOR FULL PLANT SCHEDULE

SYMBOL	CODE	BOTANICAL / COMMON NAME
--------	------	-------------------------

PARKING LOT TREES

	AO	ACER RUBRUM 'OCTOBER GLORY' / OCTOBER GLORY RED MAPLE
--	----	---

SHADE TREES

	AA	ACER RUBRUM 'ARMSTRONG' / ARMSTRONG RED MAPLE
	OO	QUERCUS X BIMUNDORUM 'CRIMSCHMIDT' / CRIMSON SPIRE™ OAK
	UO	ULMUS AMERICANA 'LEWIS & CLARK' / PRAIRIE EXPEDITION® AMERICAN ELM
	UP	ULMUS PARVIFOLIA / LACEBARK ELM
	ZM	ZELKOVA SERRATA 'MUSASHINO' / MUSASHINO JAPANESE ZELKOVA

EVERGREEN TREES

	JB	JUNIPERUS CHINENSIS 'BLUE POINT' / BLUE POINT JUNIPER
	TR	THUJA OCCIDENTALIS 'EMERALD GREEN' / EMERALD GREEN ARBORVITAE

ORNAMENTAL TREES

	CC	CERCIS CANADENSIS / EASTERN REDBUD
	MS	MALUS X 'SPRING SNOW' / SPRING SNOW CRABAPPLE

SHRUBS

	BG	BUXUS X 'GREEN GEM' / GREEN GEM BOXWOOD
	CG	CHAMAECYPARIS PISIFERA 'GOLDEN MOP' / GOLDEN MOP THREADLEAF SAWARA CYPRESS
	IS	ILEX GLABRA 'SHAMROCK' / SHAMROCK INK BERRY HOLLY
	JS	JUNIPERUS X PFITZERIANA 'SEA GREEN' / SEA GREEN PFITZER JUNIPER
	TD	TAXUS X MEDIA 'DENSIFORMIS' / DENSE ANGLo-JAPANESE YEW
	TH	THUJA OCCIDENTALIS 'HETZ MIDGET' / HETZ MIDGET ARBORVITAE

GROUND COVERS

	LV	LIRIOPE MUSCARI 'VARIEGATA' / VARIEGATED LILYTURF
--	----	---

SEED

	FT	FESTUCA ARUNDINACEA / TALL FESCUE
--	----	-----------------------------------

SOD

	FA	FESTUCA ARUNDINACEA / TALL FESCUE
--	----	-----------------------------------



ARCHITECTURAL CORPORATION
MISSOURI CERTIFICATE
OF AUTHORITY NO. 000073

LEE'S SUMMIT SENIOR COMMUNITY
 5101 NE LAKEWOOD WAY
 LEE'S SUMMIT, JACKSON COUNTY, MISSOURI 64064
 STARK WILSON DUNCAN ARCHITECTS INC.
 315 NICHOLS RD., STE 228 - KANSAS CITY, MO 64112 - T: 816.951.1898 - WWW.SWDARCHITECTS.COM

SEAL
LANDSCAPE ARCHITECT - ASHLEY SERR
LICENSE NO. PL-A-2024016720




LANDSCAPE PLAN
ENLARGEMENT 1

ISSUE DATE:
1.26.2026
REVISIONS:



PREPARED BY:
Kimley-Horn
805 PENNSYLVANIA AVENUE, SUITE 150
KANSAS CITY, MO 64105
PHONE: 816-652-0350
WWW.KIMLEY-HORN.COM
© 2025 KIMLEY-HORN AND ASSOCIATES, INC.
MO CERTIFICATE OF AUTHORITY # 2012036305,
EXPIRES 12/31/26

PROJECT NO.: 2510
L1.1
COPYRIGHT © 2025 SWD ARCHITECTS INC.

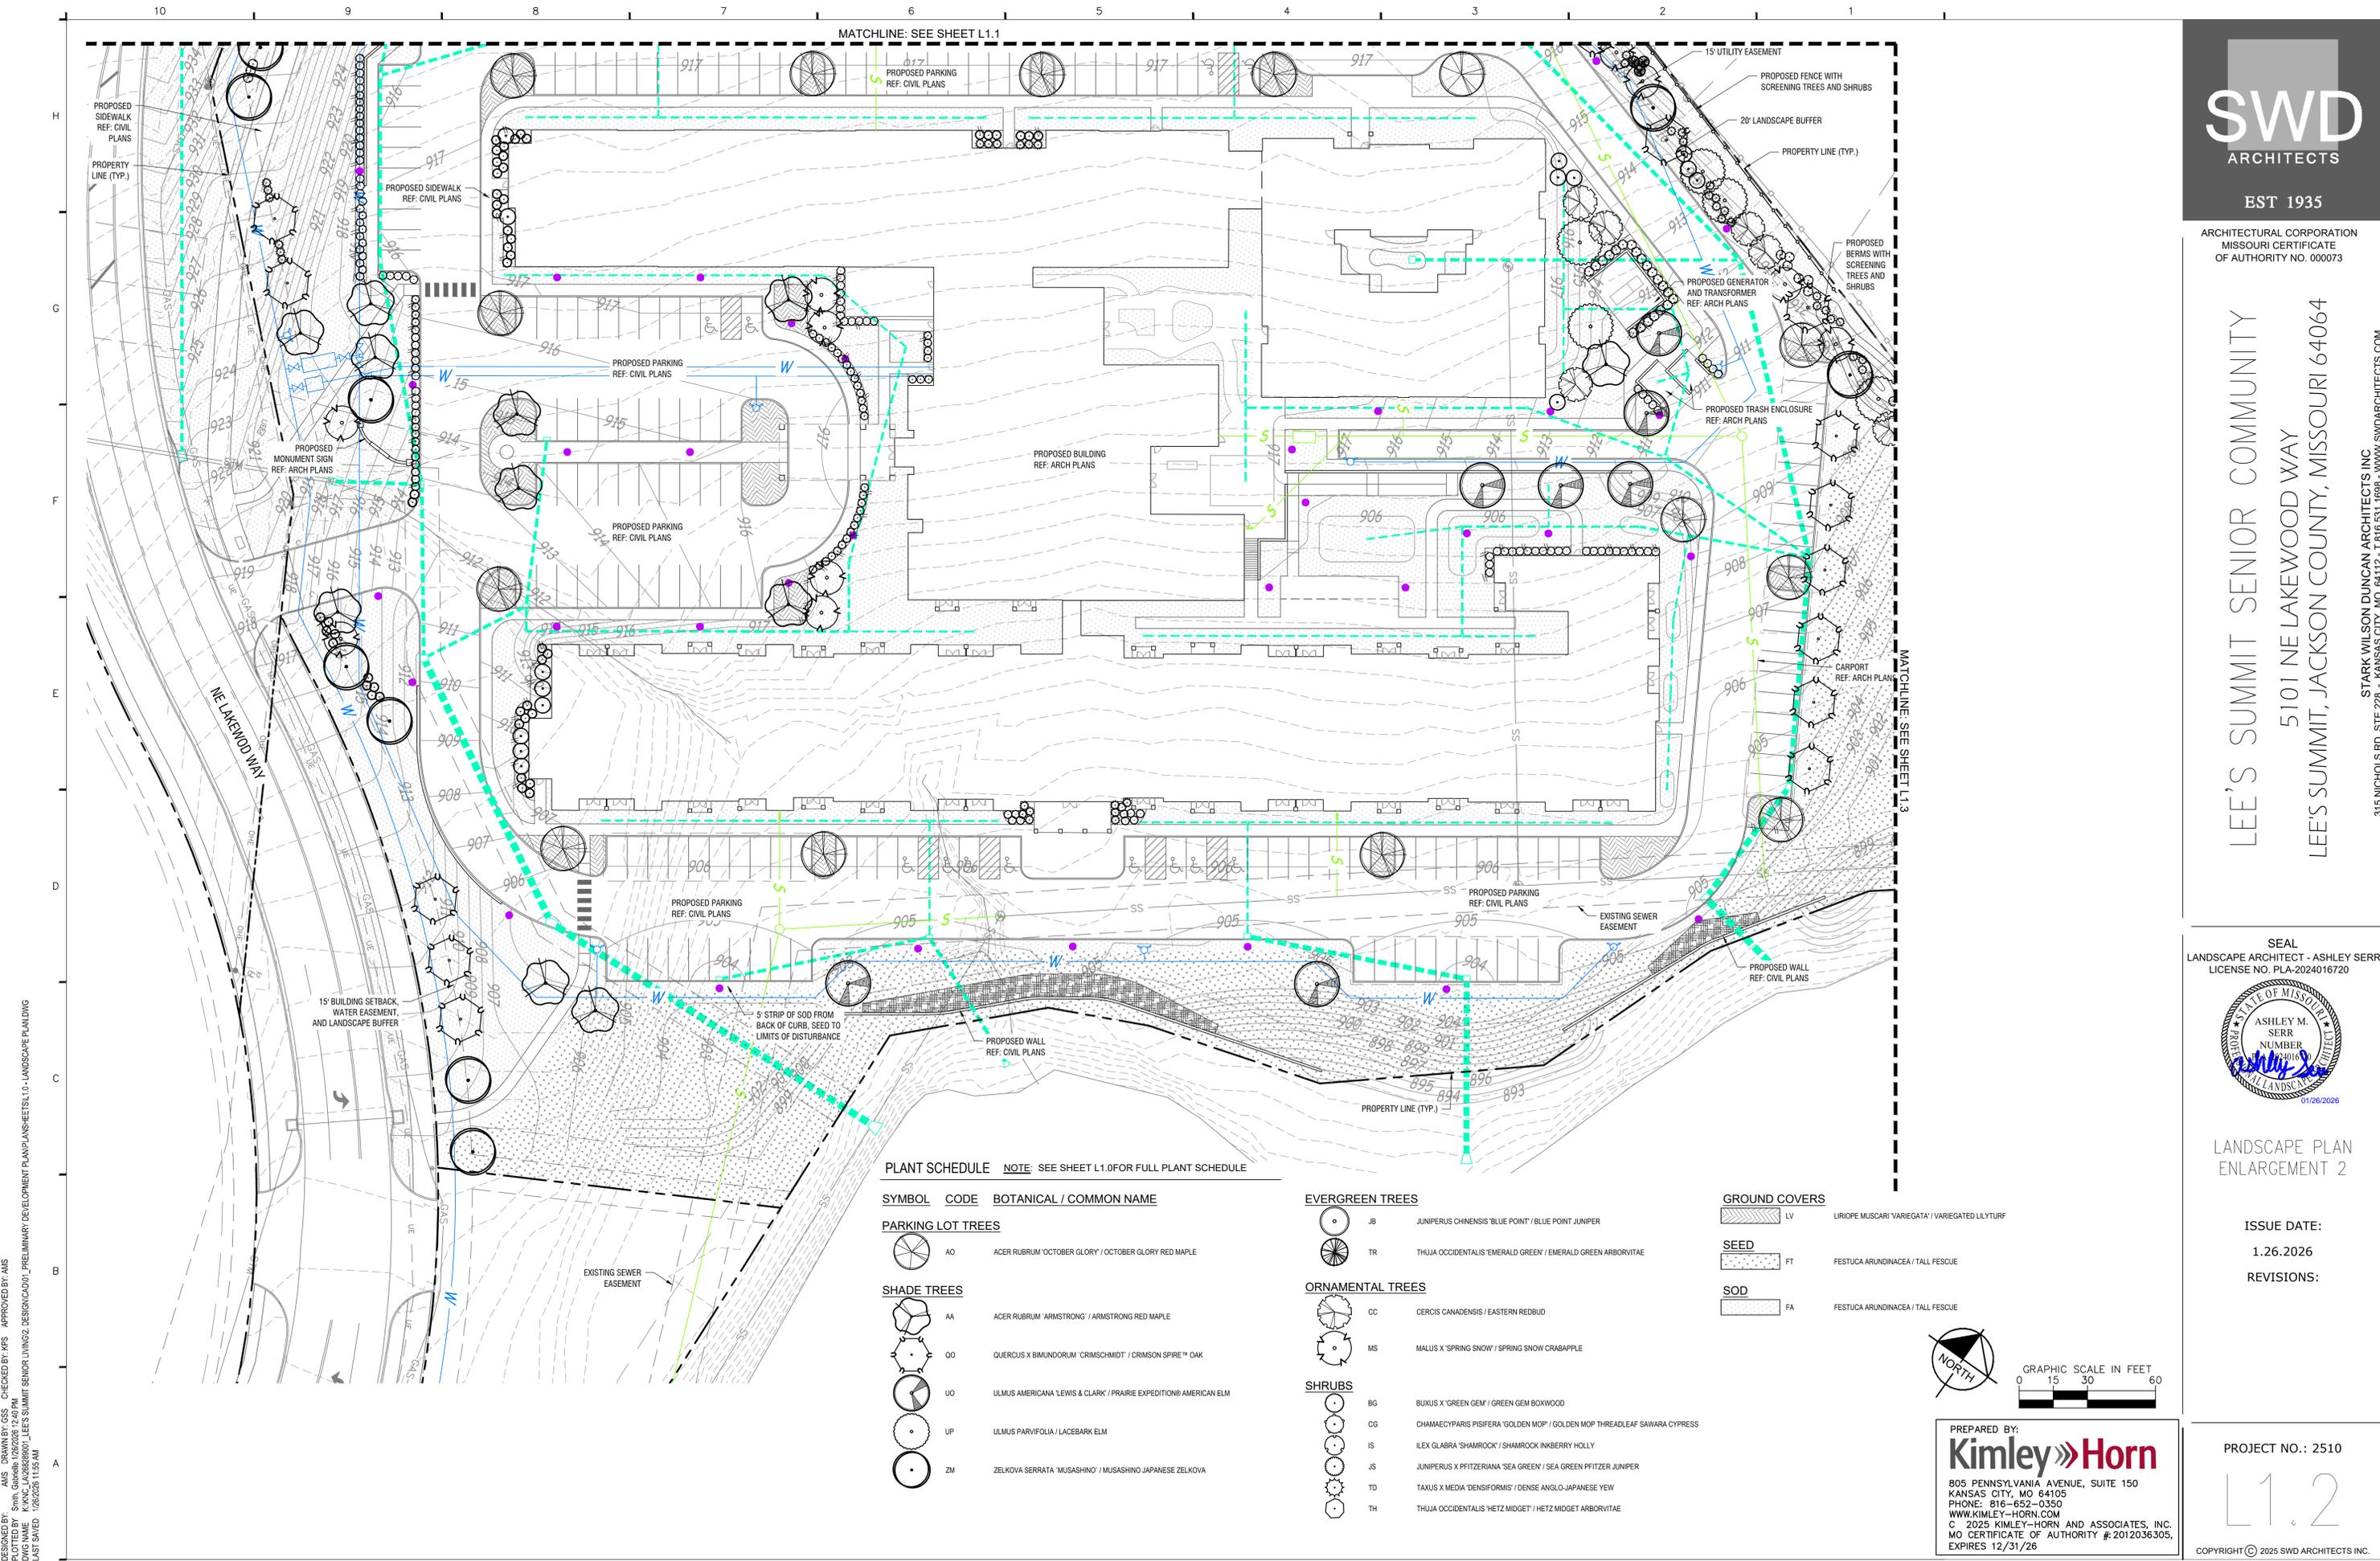


DESIGNED BY: AMS DRAWN BY: CSS CHECKED BY: KPS APPROVED BY: AMS
 DATE: 12/26/2025 11:55 AM
 DWG NAME: K:\K\2025\2510_L1.2_Preliminary Development Plans\Sheet L1.2 - Landscape Plan.dwg
 LAST SAVED: 12/26/2025 11:55 AM

PLANT SCHEDULE NOTE: SEE SHEET L1.0 FOR FULL PLANT SCHEDULE

SYMBOL	CODE	BOTANICAL / COMMON NAME
PARKING LOT TREES		
	AO	ACER RUBRUM 'OCTOBER GLORY' / OCTOBER GLORY RED MAPLE
SHADE TREES		
	AA	ACER RUBRUM 'ARMSTRONG' / ARMSTRONG RED MAPLE
	QO	QUERCUS X BIMUNDORUM 'CRIMSCHMIDT' / CRIMSON SPIRE™ OAK
	UO	ULMUS AMERICANA 'LEWIS & CLARK' / PRAIRIE EXPEDITION® AMERICAN ELM
	UP	ULMUS PARVIFOLIA / LACEBARK ELM
	ZM	ZELKOVA SERRATA 'MUSASHINO' / MUSASHINO JAPANESE ZELKOVA

EVERGREEN TREES		
	JB	JUNIPERUS CHINENSIS 'BLUE POINT' / BLUE POINT JUNIPER
	TR	THUJA OCCIDENTALIS 'EMERALD GREEN' / EMERALD GREEN ARBORVITAE
ORNAMENTAL TREES		
	CC	CERCIS CANADENSIS / EASTERN REDBUD
	MS	MALUS X 'SPRING SNOW' / SPRING SNOW CRABAPPLE
SHRUBS		
	BG	BUXUS X 'GREEN GEM' / GREEN GEM BOXWOOD
	CG	CHAMAECYPARIS PISIFERA 'GOLDEN MOP' / GOLDEN MOP THREADLEAF SAWARA CYPRESS
	IS	ILEX GLABRA 'SHAMROCK' / SHAMROCK INKBERY HOLLY
	JS	JUNIPERUS X PFITZERRIANA 'SEA GREEN' / SEA GREEN PFITZER JUNIPER
	TD	TAXUS X MEDIA 'DENSIFORMIS' / DENSE ANGLO-JAPANESE YEW
	TH	THUJA OCCIDENTALIS 'HETZ MIDGET' / HETZ MIDGET ARBORVITAE

GROUND COVERS		
	LV	LIRIOPE MUSCARI 'VARIEGATA' / VARIEGATED LILYTURF
SEED		
	FT	FESTUCA ARUNDINACEA / TALL FESCUE
SOD		
	FA	FESTUCA ARUNDINACEA / TALL FESCUE

 

PREPARED BY:
Kimley Horn
 805 PENNSYLVANIA AVENUE, SUITE 150
 KANSAS CITY, MO 64105
 PHONE: 816-652-0350
 WWW.KIMLEY-HORN.COM
 © 2025 KIMLEY-HORN AND ASSOCIATES, INC.
 MO CERTIFICATE OF AUTHORITY # 2012036305,
 EXPIRES 12/31/26

EST 1935

ARCHITECTURAL CORPORATION
 MISSOURI CERTIFICATE
 OF AUTHORITY NO. 000073

LEE'S SUMMIT SENIOR COMMUNITY
 5101 NE LAKEWOOD WAY
 LEE'S SUMMIT, JACKSON COUNTY, MISSOURI 64064

STARK WILSON DUNCAN ARCHITECTS INC.
 315 NICHOLS RD., STE 228 - KANSAS CITY, MO 64112 - T: 816.951.1888 - WWW.SWDARCHITECTS.COM

SEAL
 LANDSCAPE ARCHITECT - ASHLEY SERR
 LICENSE NO. PL-A-2024016720

LANDSCAPE PLAN
ENLARGEMENT 2

ISSUE DATE:
 1.26.2026
 REVISIONS:

PROJECT NO.: 2510
L1.2
 COPYRIGHT © 2025 SWD ARCHITECTS INC.



DESIGNED BY: AMS DRAWN BY: CSS CHECKED BY: RPS APPROVED BY: AMS
 DATE: 1/26/2026 11:55 AM
 FILE NAME: K:\KVC\1038288001_LEE'S SUMMIT SENIOR LIVING\2. DESIGN\001_PRELIMINARY DEVELOPMENT PLAN\LANDSCAPE PLAN\DWG

PLANT SCHEDULE NOTE: SEE SHEET L1.0 FOR FULL PLANT SCHEDULE

SYMBOL	CODE	BOTANICAL / COMMON NAME
--------	------	-------------------------

PARKING LOT TREES

	AO	ACER RUBRUM 'OCTOBER GLORY' / OCTOBER GLORY RED MAPLE
--	----	---

SHADE TREES

	AA	ACER RUBRUM 'ARMSTRONG' / ARMSTRONG RED MAPLE
	OO	QUERCUS X BIMUNDORUM 'CRIMSCHMIDT' / CRIMSON SPIRE™ OAK
	UO	ULMUS AMERICANA 'LEWIS & CLARK' / PRAIRIE EXPEDITION® AMERICAN ELM
	UP	ULMUS PARVIFOLIA / LACEBARK ELM
	ZM	ZELKOVA SERRATA 'MUSASHINO' / MUSASHINO JAPANESE ZELKOVA

EVERGREEN TREES

	JB	JUNIPERUS CHINENSIS 'BLUE POINT' / BLUE POINT JUNIPER
	TR	THUJA OCCIDENTALIS 'EMERALD GREEN' / EMERALD GREEN ARBORVITAE

ORNAMENTAL TREES

	CC	CERCIS CANADENSIS / EASTERN REDBUD
	MS	MALUS X 'SPRING SNOW' / SPRING SNOW CRABAPPLE

SHRUBS

	BG	BUXUS X 'GREEN GEM' / GREEN GEM BOXWOOD
	CG	CHAMAECYPARIS PISIFERA 'GOLDEN MOP' / GOLDEN MOP THREADLEAF SAWARA CYPRESS
	IS	ILEX GLABRA 'SHAMROCK' / SHAMROCK INK BERRY HOLLY
	JS	JUNIPERUS X PFIZERIANA 'SEA GREEN' / SEA GREEN PFIZER JUNIPER
	TD	TAXUS X MEDIA 'DENSIFORMIS' / DENSE ANGLo-JAPANESE YEW
	TH	THUJA OCCIDENTALIS 'HETZ MIDGET' / HETZ MIDGET ARBORVITAE

GROUND COVERS

	LV	LIRIOPE MUSCARI 'VARIEGATA' / VARIEGATED LILY TURF
--	----	--

SEED

	FT	FESTUCA ARUNDINACEA / TALL FESCUE
--	----	-----------------------------------

SOD

	FA	FESTUCA ARUNDINACEA / TALL FESCUE
--	----	-----------------------------------



ARCHITECTURAL CORPORATION
MISSOURI CERTIFICATE
OF AUTHORITY NO. 000073

LEE'S SUMMIT SENIOR COMMUNITY
 5101 NE LAKEWOOD WAY
 LEE'S SUMMIT, JACKSON COUNTY, MISSOURI 64064

 
STARK WILSON DUNCAN ARCHITECTS INC.
 315 NICHOLS RD., STE 228 - KANSAS CITY, MO 64112 - T: 816.951.1898 - WWW.SWDARCHITECTS.COM

SEAL
LANDSCAPE ARCHITECT - ASHLEY SERR
LICENSE NO. FLA-2024016720



LANDSCAPE PLAN
ENLARGEMENT 3


ISSUE DATE:
1.26.2026
REVISIONS:




PREPARED BY:
Kimley-Horn
 805 PENNSYLVANIA AVENUE, SUITE 150
 KANSAS CITY, MO 64105
 PHONE: 816-652-0350
 WWW.KIMLEY-HORN.COM
 © 2025 KIMLEY-HORN AND ASSOCIATES, INC.
 MO CERTIFICATE OF AUTHORITY # 2012036305,
 EXPIRES 12/31/26

PROJECT NO.: 2510


L1.3

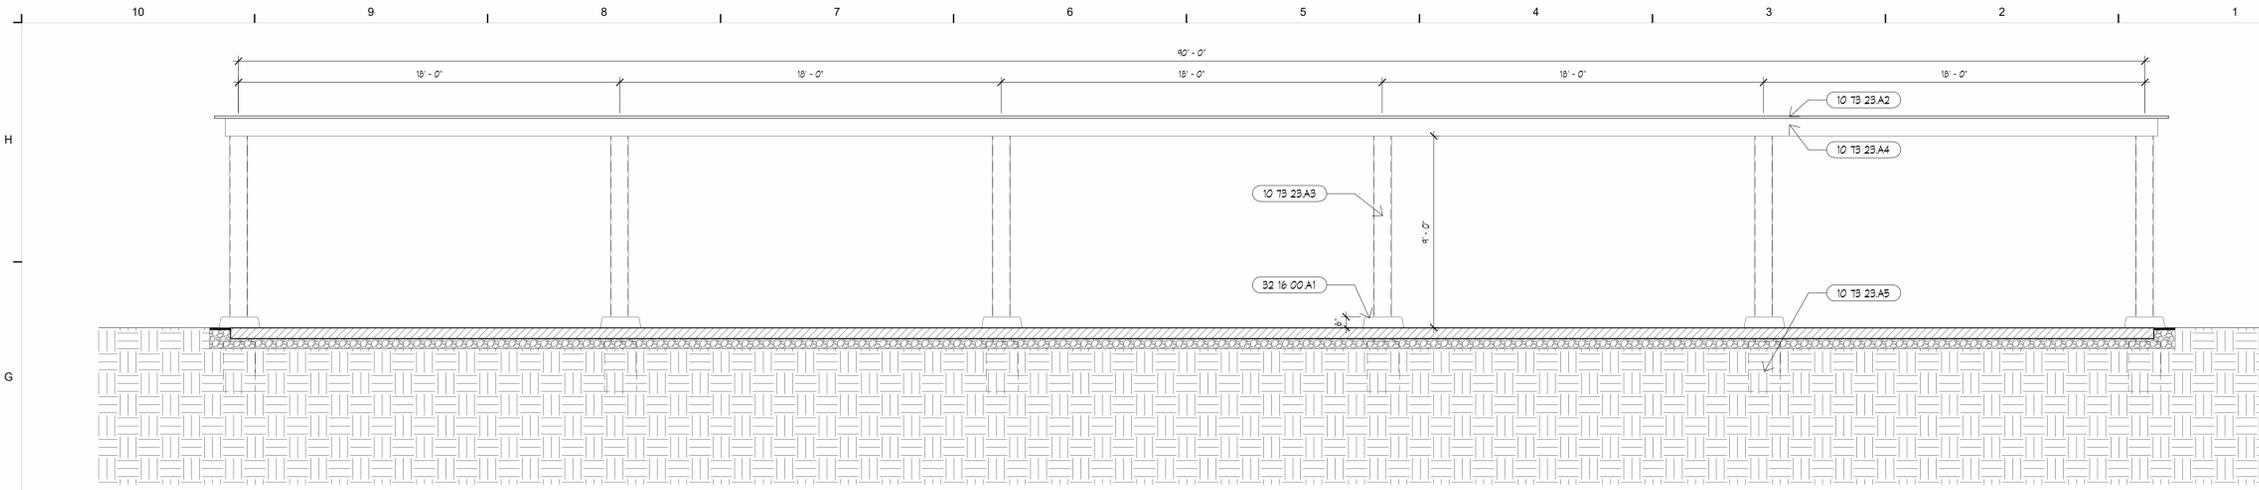


F10 SITE - CARPORT - SIDE
1/4" = 1'-0"

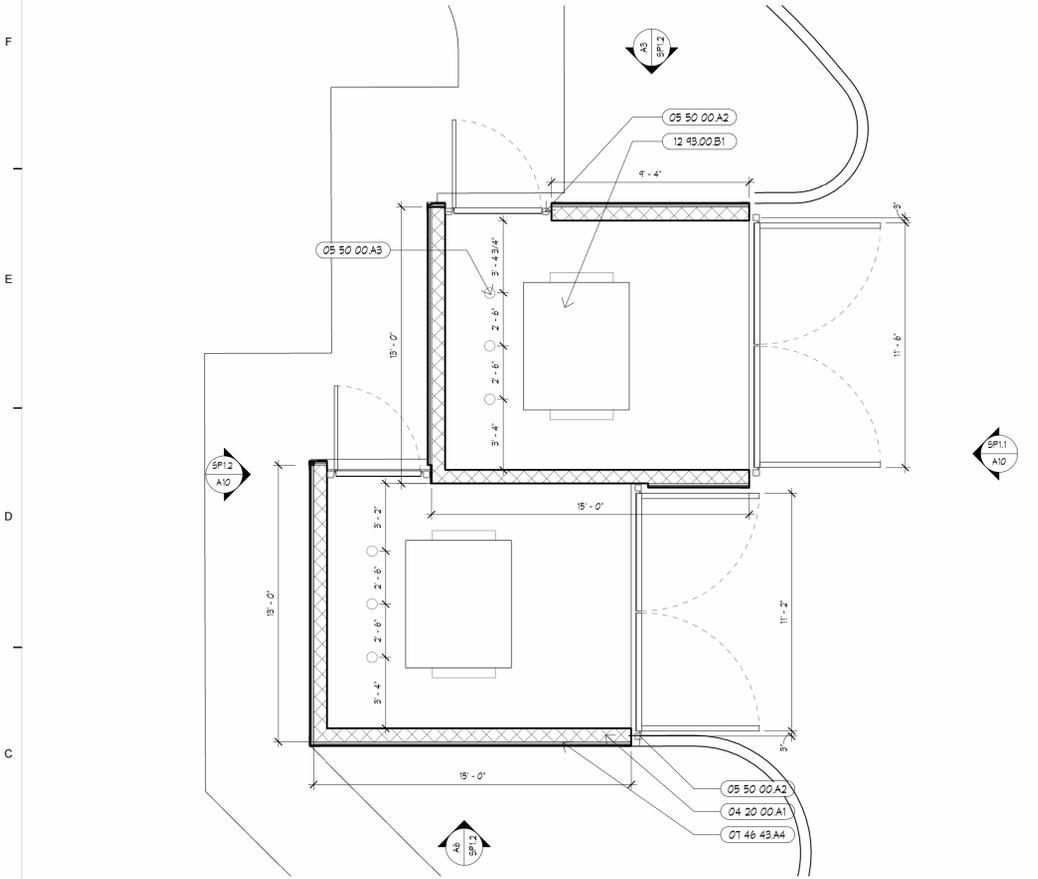


B10 SITE PLAN - TRASH ENCLOSURE
1/4" = 1'-0"

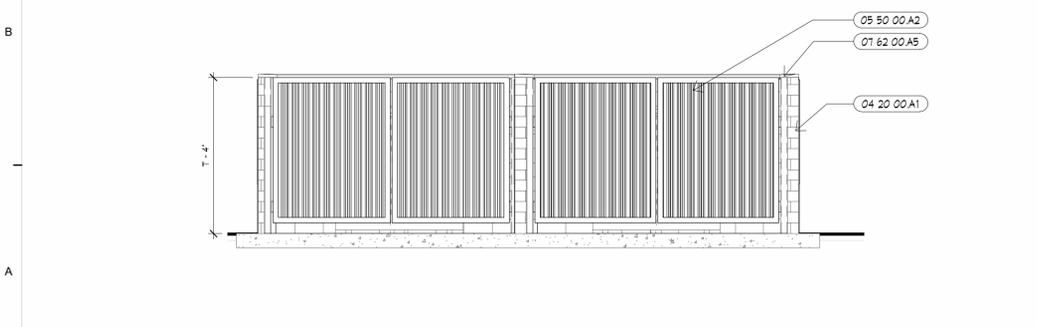


A10 SITE - TRASH ENCLOSURE FRONT
1/4" = 1'-0"

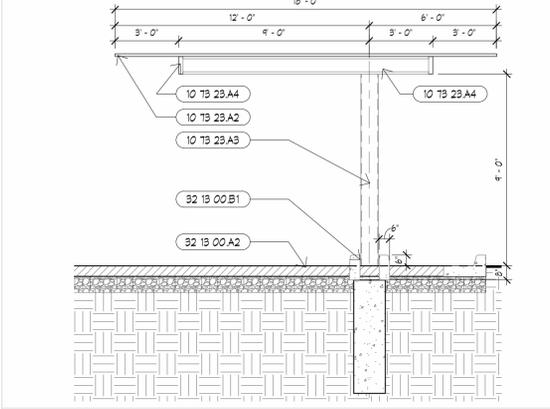


D6 SITE - CARPORT - FRONT
1/4" = 1'-0"

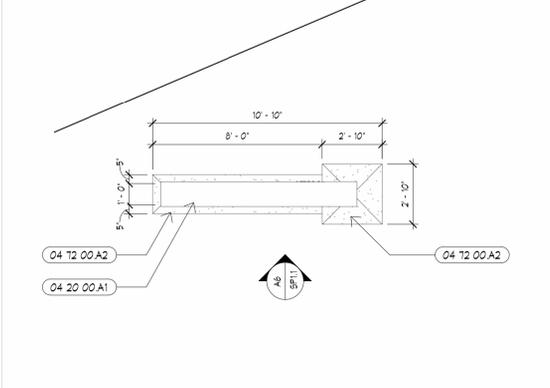

B6 PLAN AT MONUMENT SIGN
1/4" = 1'-0"

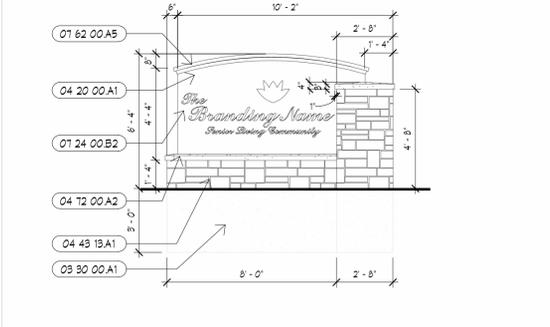

A6 SITE - MONUMENT SIGN 1
1/4" = 1'-0"

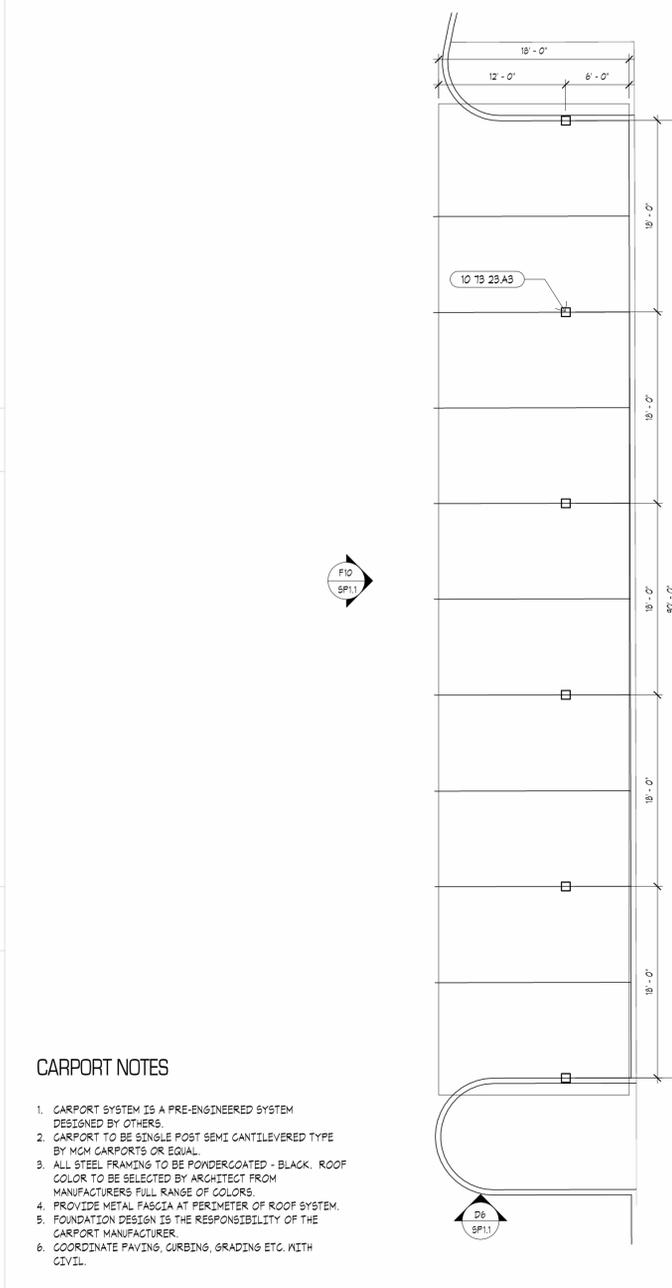

A3 SITE PLAN - CARPORT
1/8" = 1'-0"

CARPORT NOTES

- CARPORT SYSTEM IS A PRE-ENGINEERED SYSTEM DESIGNED BY OTHERS.
- CARPORT TO BE SINGLE POST SEMI CANTILEVERED TYPE BY MCM CARPORTS OR EQUAL.
- ALL STEEL FRAMING TO BE POWDERCOATED - BLACK. ROOF COLOR TO BE SELECTED BY ARCHITECT FROM MANUFACTURERS FULL RANGE OF COLORS.
- PROVIDE METAL FASCIA AT PERIMETER OF ROOF SYSTEM.
- FOUNDATION DESIGN IS THE RESPONSIBILITY OF THE CARPORT MANUFACTURER.
- COORDINATE PAVING, CURBING, GRADING ETC. WITH CIVIL.

KEYNOTES

NUMBER	DESCRIPTION
03 30 00A1	REINFORCED CONCRETE FOUNDATION. RE: STRUCTURAL. 03 30 00
04 20 00A1	8" REINFORCED CMU. RE: STRUCTURAL. 04 20 00
04 43 13A1	MANUFACTURED STONE VENEER. TYPE 1 04 43 13
04 72 00A2	CAST STONE CAP. 04 72 00
05 50 00A2	PAINTED STEEL POST AND GATE FRAME. 05 50 00
05 50 00A3	6" STEEL PIPE BOLLARD. 05 50 00
07 24 00B2	EITFS COATING OVER CMU. ALL EXPOSED SURFACES.
07 46 43A4	FIBER CEMENT BOARD SIDING - VERTICAL BOARD 1 BAT. 07 46 43
07 62 00A5	PRE FINISHED METAL CAP FLASHING. 07 62 00
10 TB 23A2	PRE-ENGINEERED METAL ROOFING PANEL. 10 TB 23
10 TB 23A3	PRE-ENGINEERED STEEL COLUMN. PER MANUF.
10 TB 23A4	PRE-ENGINEERED STEEL BEAM. PER MANUF.
10 TB 23A5	CONCRETE FOOTING. PER MANUF.
12 43 00B1	DUMPSTER - BY OWNER.
32 13 00A2	CONCRETE PAVING. RE: CIVIL
32 13 00B1	EXPANSION JOINT. FIBER EXPANSION MATERIAL W/ TOP 1/2" FILLED W/ SEALANT
32 16 00A1	6" CONCRETE CURB.



ARCHITECTURAL CORPORATION
MISSOURI CERTIFICATE
OF AUTHORITY NO. 000073

LEES SUMMIT SENIOR COMMUNITY
5101 NE LAKEWOOD WAY
LEES SUMMIT, JACKSON COUNTY, MISSOURI 64064

SEAL
ARCHITECT - TIMOTHY O.K. WILSON
LICENSE NO. A-6972



SITE DETAILS

ISSUE DATE:
1.26.2026

REVISIONS:
NO. DESCRIPTION DATE

- NOTES:**
- COORDINATE PAVING & CURB WITH CIVIL.
 - TRASH DUMPSTERS PROVIDED BY OWNERS VENDOR.
 - ALL STEEL IS TO BE PAINTED.
 - STEEL BOLLARDS TO BE FILLED WITH CONCRETE & ROUNDED OVER.
 - COORD. FOUNDATION W/ STRUCTURAL.

MONUMENT SIGN NOTES

- ALL SIGNAGE TO BE PERMITTED SEPARATELY.
- LOGO AND TEXT WILL BE TYPICAL FOR BOTH SIDES. THIS WILL BE PROVIDED DURING SHOP DRAWING SUBMITTALS.
- SIGN CONTRACTOR WILL BE RESPONSIBLE FOR OBTAINING ALL PERMITS ASSOCIATED WITH THE MONUMENT SIGN.

PROJECT NO.: 2510
SP1.1

C:\Users\dtruskey\Documents\ORD_LEE'S SUMMIT II - 01 SENIOR LIVING_dtruskey\6YP6R.rvt
1/23/2026 2:25:26 PM

NUMBER	DESCRIPTION
04 20 00A1	8" REINFORCED CMU. RE: STRUCTURAL. 04 20 00
04 43 19A1	MANUFACTURED STONE VENEER. TYPE 1 04 43 19
04 72 00A2	CAST STONE CAP. 04 72 00
05 50 00A2	PAINTED STEEL POST AND GATE FRAME. 05 05 00
01 24 00A1	EXTERIOR INSULATION & FINISH SYSTEM. 01 24 00
01 46 43A1	FIBER CEMENT BOARD SIDING - HORIZONTAL LAP. 01 46 43
01 46 43A3	FIBER CEMENT BOARD TRIM. 01 46 43
01 62 00A5	PRE FINISHED METAL CAP FLASHING. 01 62 00
10 14 00A3	CUT LETTERS AND GRAPHICS. COORD. WITH OWNER. 10 14 26
32 31 00A1	PRE-FINISHED 6" VINYL FENCE. 32 31 00



ARCHITECTURAL CORPORATION
MISSOURI CERTIFICATE
OF AUTHORITY NO. 000073

LEES SUMMIT SENIOR COMMUNITY
5101 NE LAKEWOOD WAY
LEES SUMMIT, JACKSON COUNTY, MISSOURI 64064

STARK WILSON DUNCAN ARCHITECTS INC
315 NICHOLS ROAD STE 228 - KANSAS CITY, MO 64112 - T 816.531.1698
WWW.SWDARCHITECTS.COM

SEAL
ARCHITECT - TIMOTHY O.K. WILSON
LICENSE NO. A-6972




SITE DETAILS

ISSUE DATE:
1.26.2026
REVISIONS:
NO. DESCRIPTION DATE


PROJECT NO.: 2510

SP1.2


COPYRIGHT © 2025 SWD ARCHITECTS INC

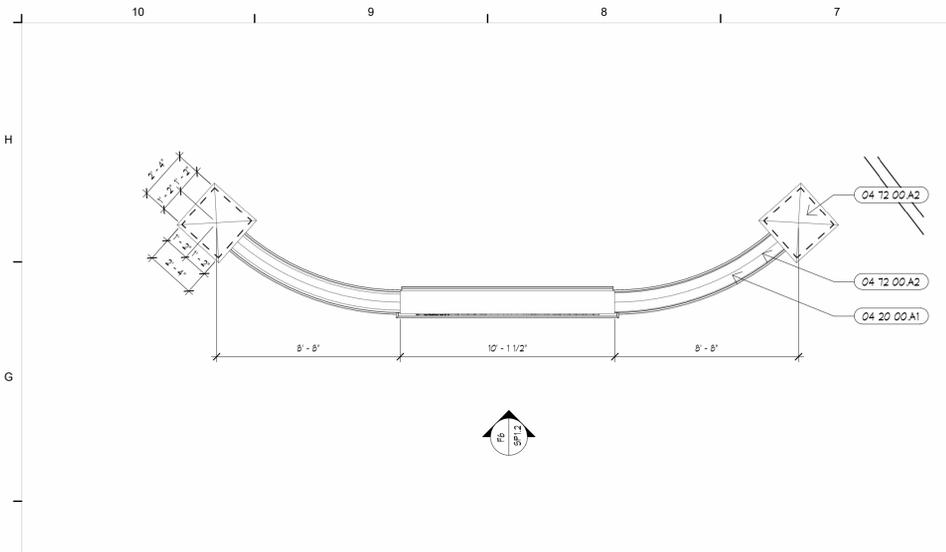


F10 SITE PLAN - MONUMENT SIGN 2
1/4" = 1'-0"

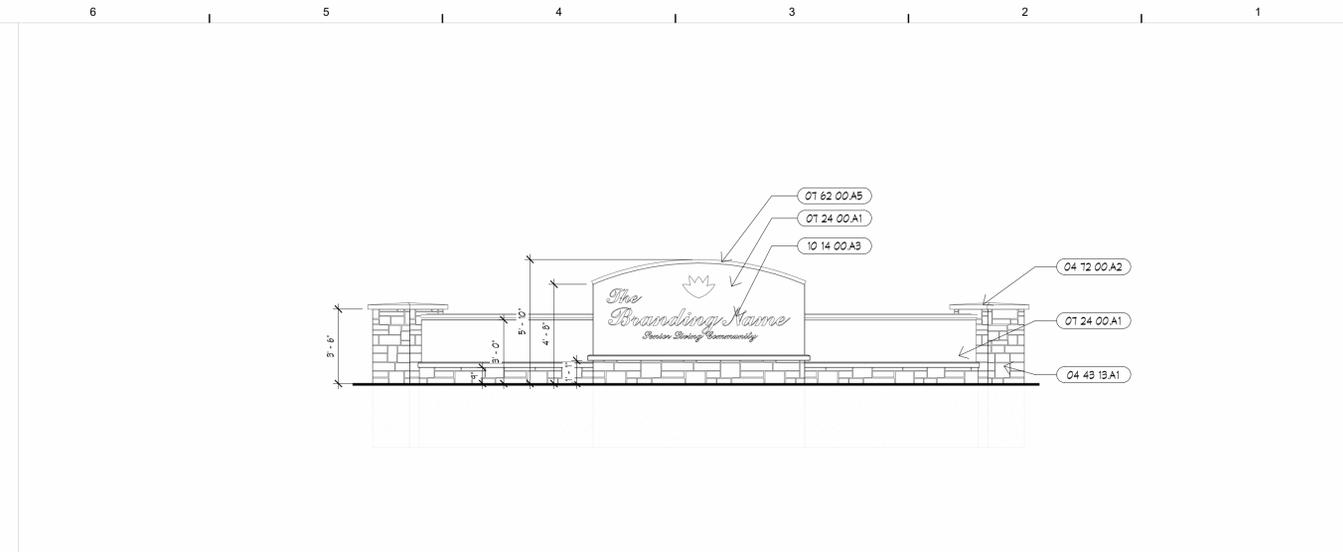


F6 ELEVATION AT MONUMENT SIGN 2
1/4" = 1'-0"

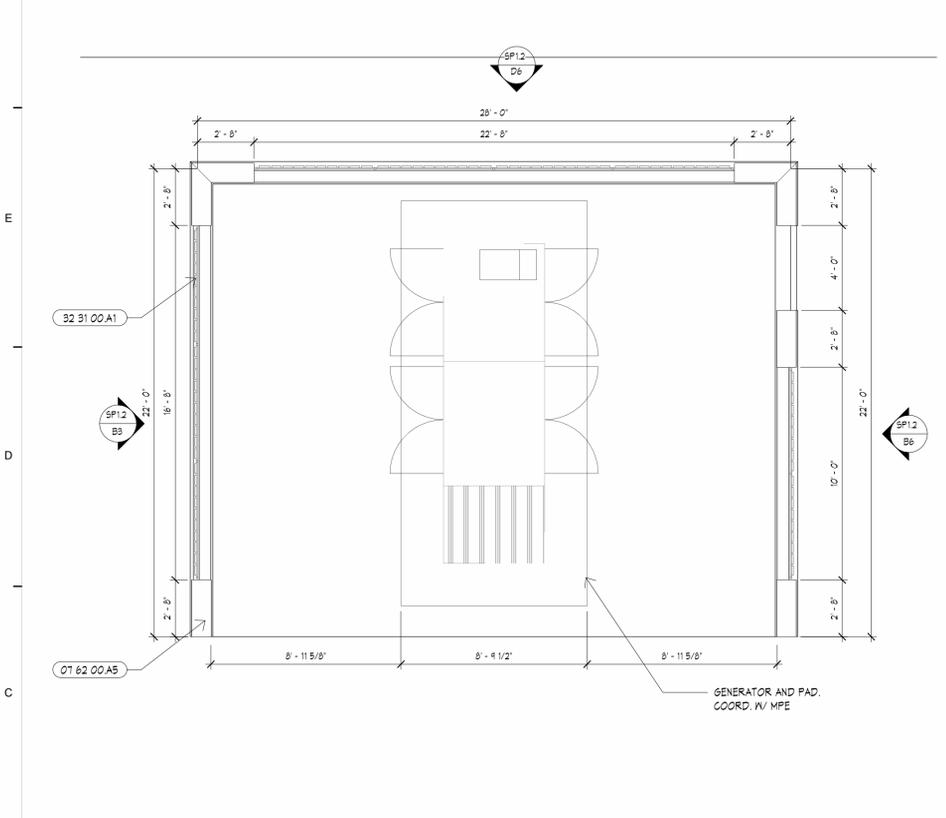


B10 SITE PLAN - GENERATOR ENCLOSURE
1/4" = 1'-0"

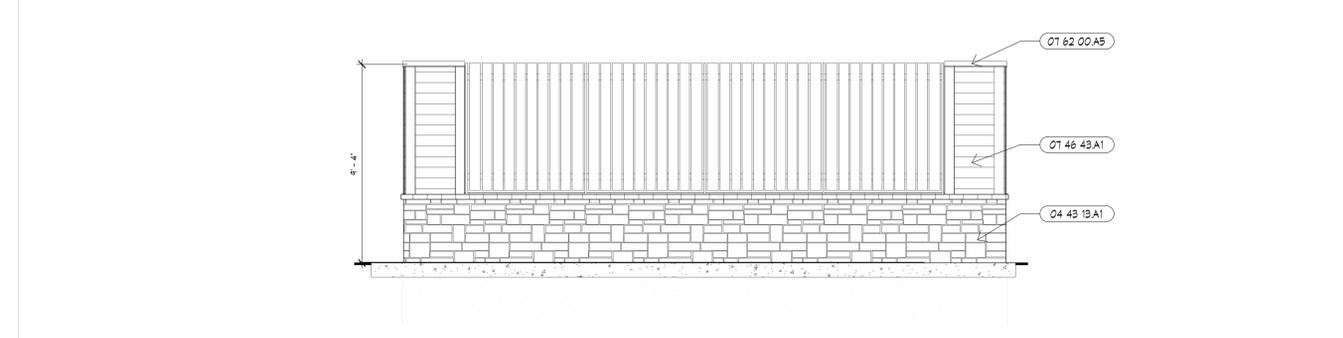


D6 SITE - GENERATOR ENCLOSURE - FRONT
1/4" = 1'-0"

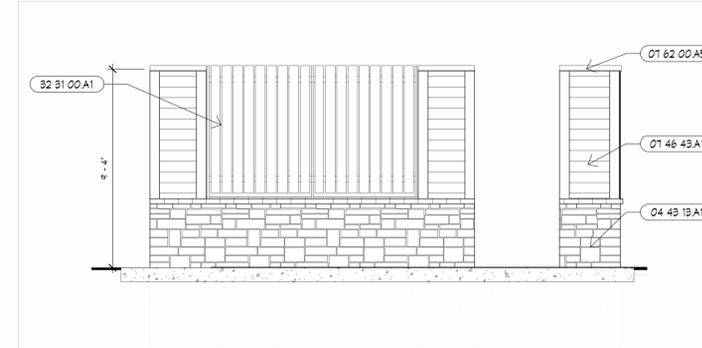


B6 SITE - GENERATOR ENCLOSURE - SIDE DOOR
1/4" = 1'-0"

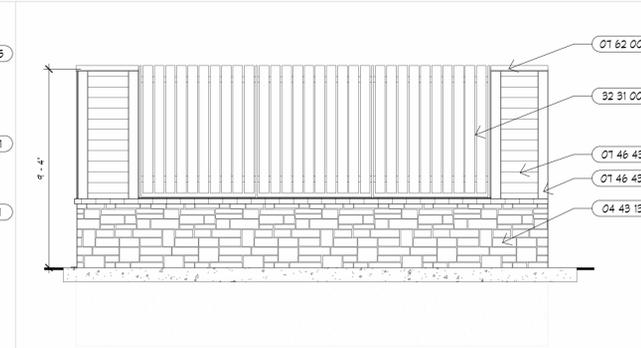


B3 SITE - GENERATOR ENCLOSURE - SIDE
1/4" = 1'-0"

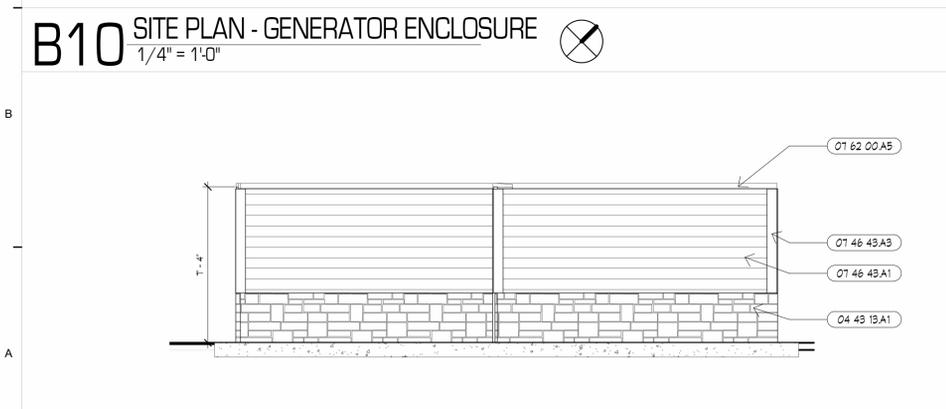

A10 SITE - TRASH ENCLOSURE REAR
1/4" = 1'-0"

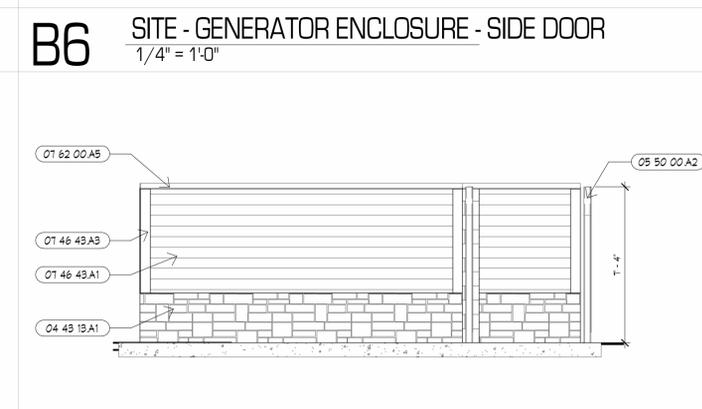



A6 SITE - TRASH ENCLOSURE SIDE
1/4" = 1'-0"

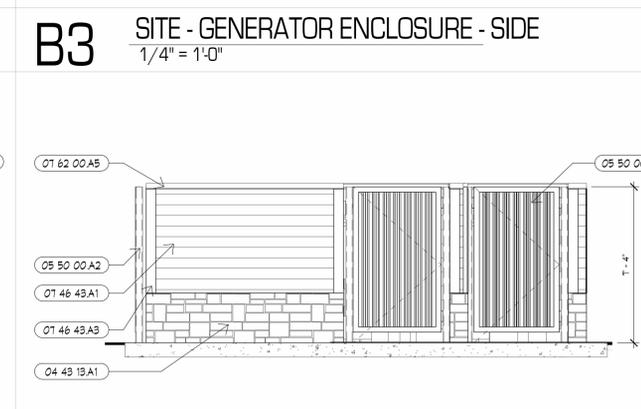



A3 SITE - TRASH ENCLOSURE SIDE
1/4" = 1'-0"

C:\Users\dtruskey\Documents\ORD LEE'S SUMMIT II - 01 SENIOR LIVING.dtruskey\6YP6R.rvt
1/23/2026 2:25:39 PM


 
C:\Users\dtruskey\Documents\ORD LEE'S SUMMIT II - 01 SENIOR LIVING_dtruskey\6YP6R.rvt
 1/23/2026 2:25:47 PM

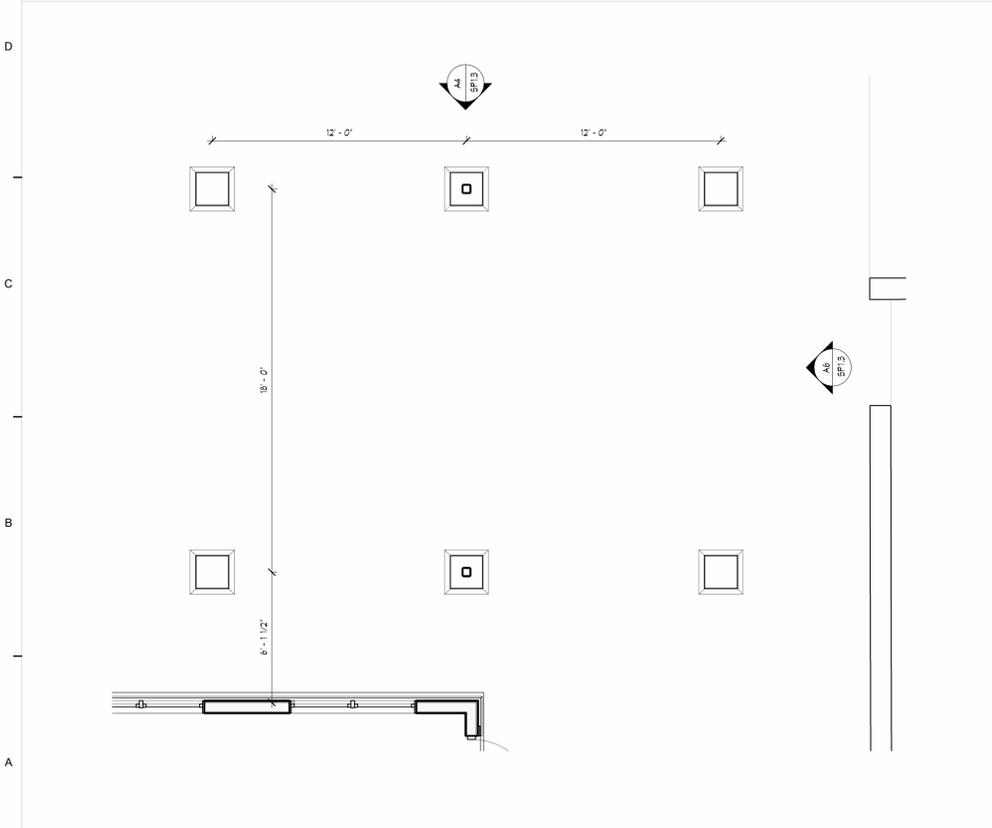

A10 SITE PLAN - PAVILION
 1/4" = 1'-0"

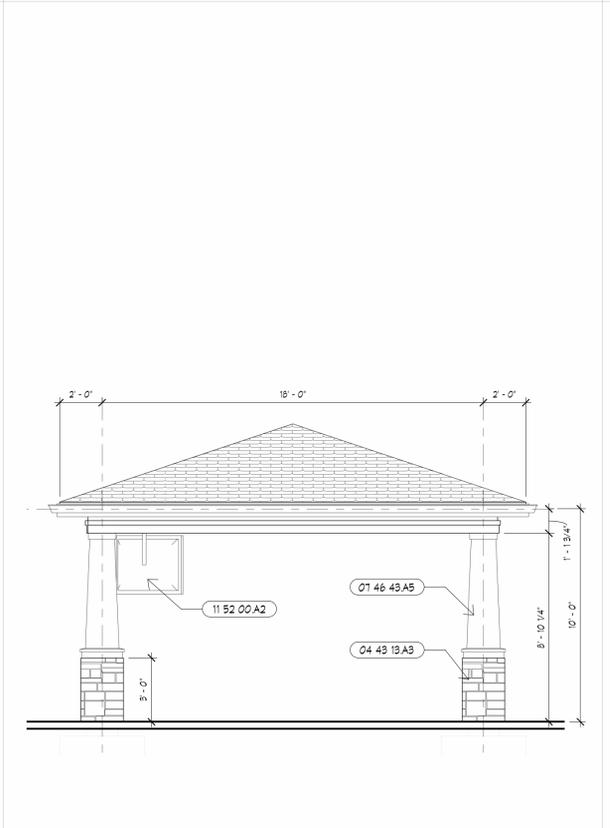 


A6 ELEVATION AT PAVILION
 1/4" = 1'-0"

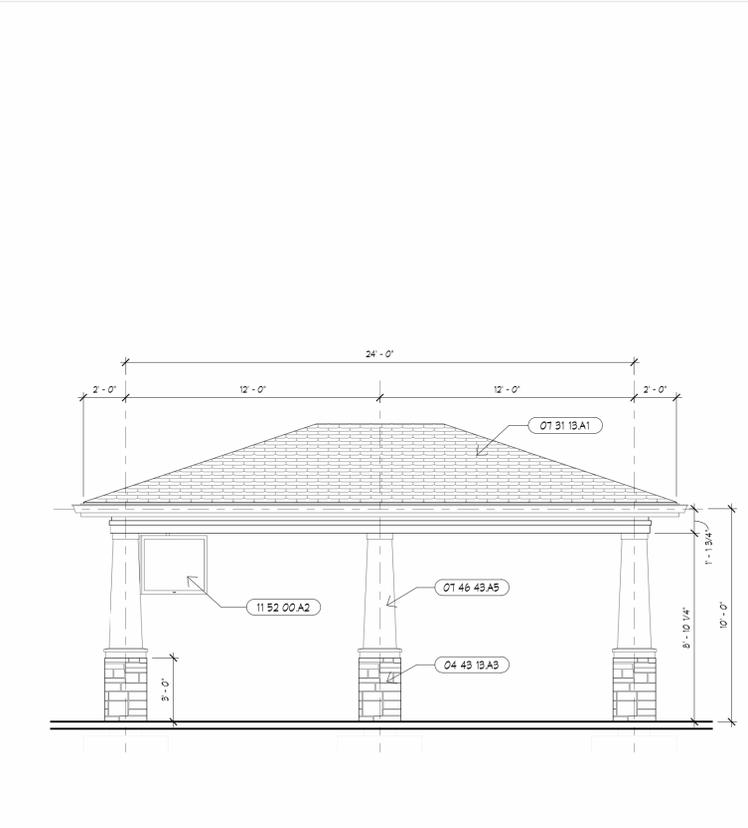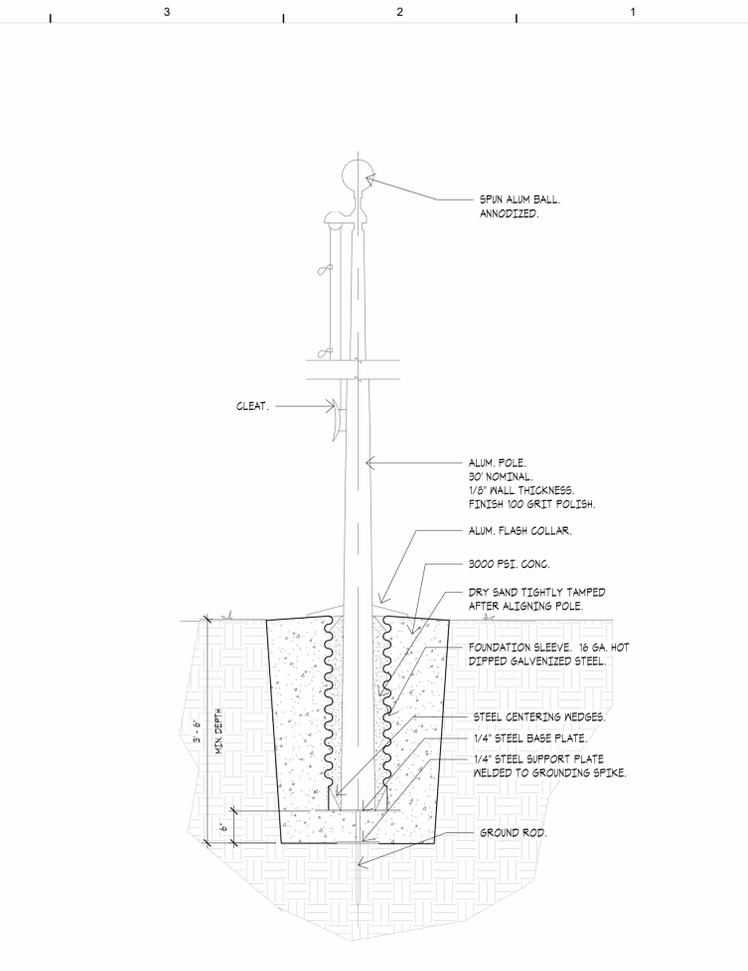

A4 ELEVATION AT PAVILION
 1/4" = 1'-0"

NUMBER	DESCRIPTION
04 43 13 A3	MANUFACTURED STONE CAP, 04 43 13
01 31 13 A1	ARCHITECTURAL ASPHALT SHINGLE, 01 31 13
01 46 43 A5	FIBER CEMENT BOARD SIDING - SMOOTH PANEL, 01 46 43
11 52 00 A2	TELEVISION - 85". RE: LOW VOLTAGE

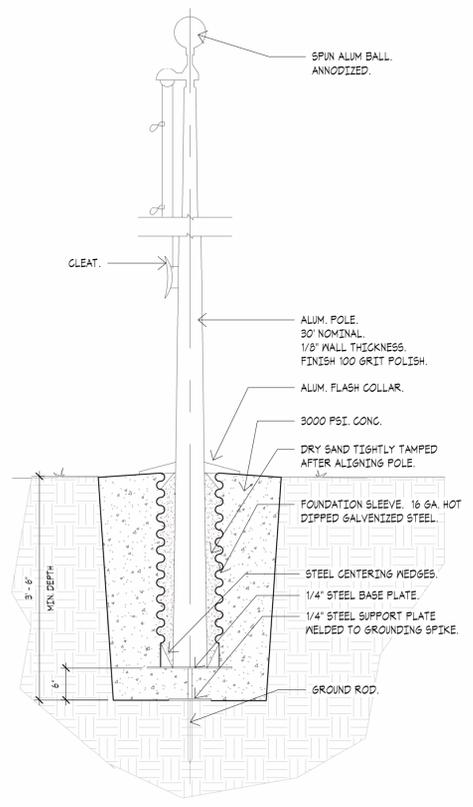

D4 FLAGPOLE DETAIL
 3/4" = 1'-0"



ARCHITECTURAL CORPORATION
 MISSOURI CERTIFICATE
 OF AUTHORITY NO. 000073

LEES SUMMIT SENIOR COMMUNITY
 5101 NE LAKEWOOD WAY
 LEES SUMMIT, JACKSON COUNTY, MISSOURI 64064

STARK WILSON DUNCAN ARCHITECTS INC
 315 NICHOLS ROAD STE 228 - KANSAS CITY, MO 64112 - T 816.531.1698
 WWW.SWDARCHITECTS.COM

SEAL
 ARCHITECT - TIMOTHY O.K. WILSON
 LICENSE NO. A-6972




SITE DETAILS


ISSUE DATE:
 1.26.2026
 REVISIONS:
 NO. DESCRIPTION DATE

PROJECT NO.: 2510
SP1.3

C:\Users\dtruskey\Documents\ORD LEE'S SUMMIT II - 01 SENIOR LIVING_dtruskey\YP6R.rvt
 1/23/2026 2:26:37 PM

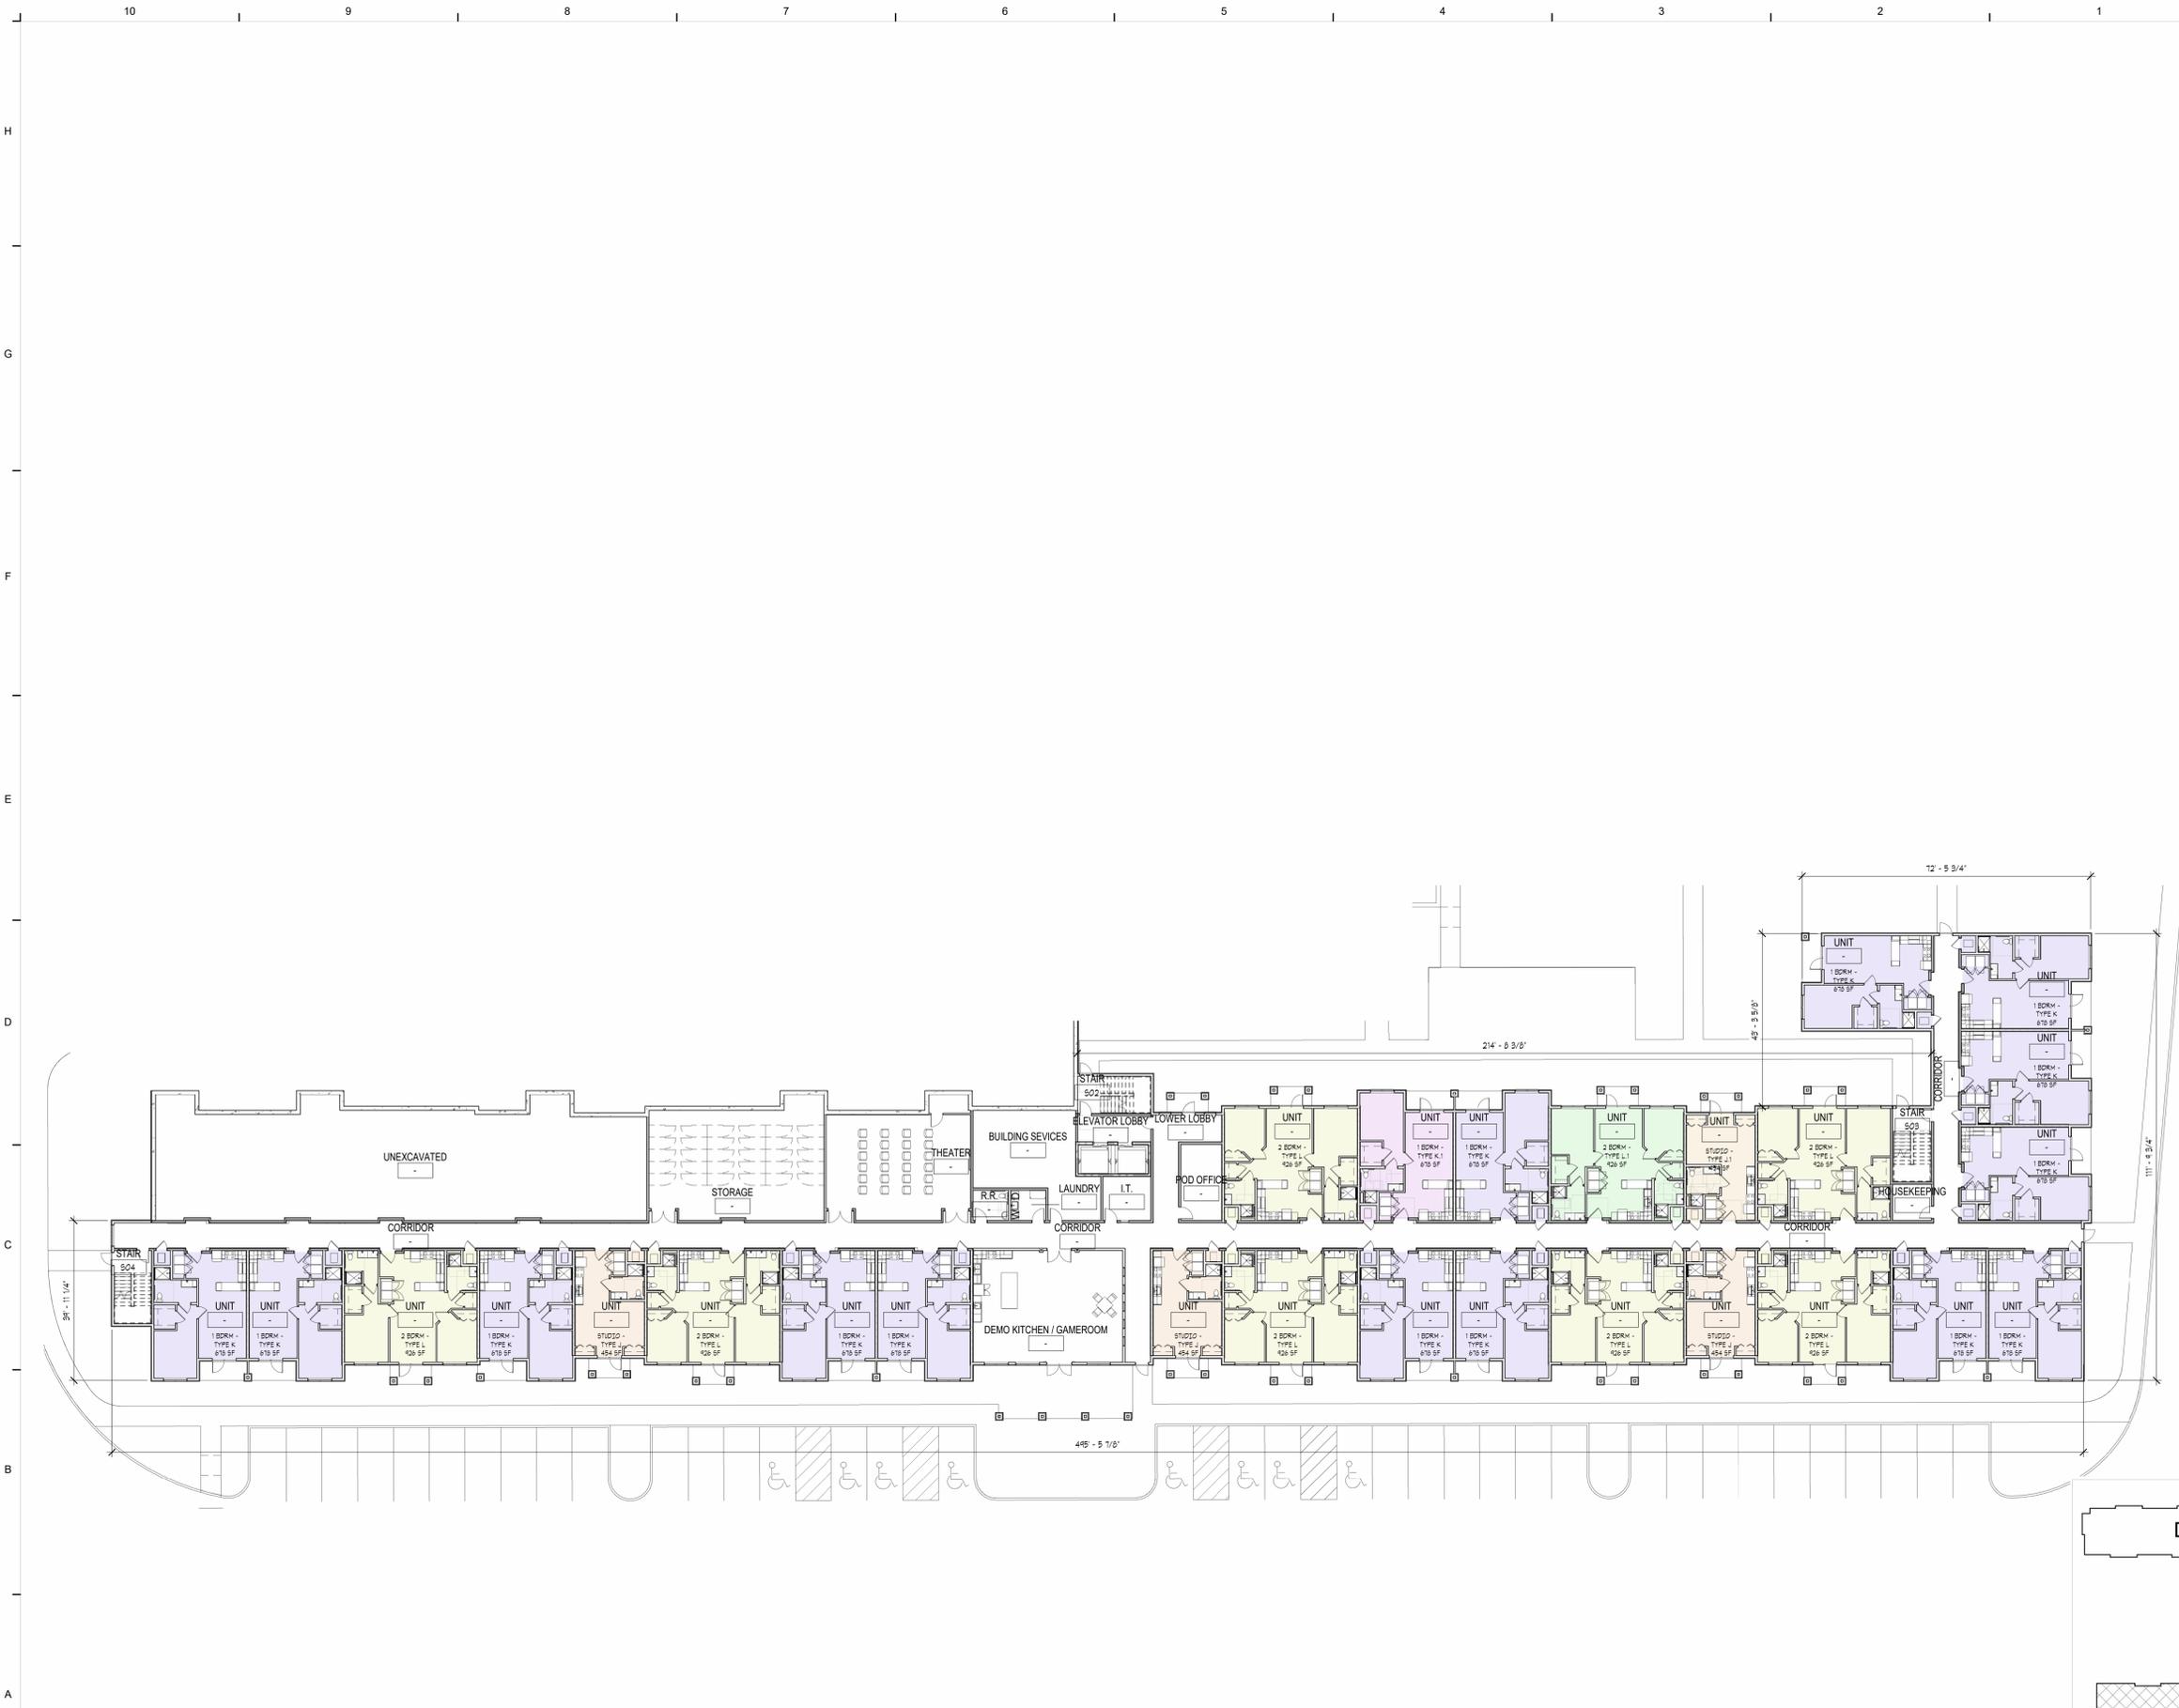

- Room Legend**
- 1 BDRM - TYPE K
 - 1 BDRM - TYPE K.1
 - 2 BDRM - TYPE L
 - 2 BDRM - TYPE L.1
 - STUDIO - TYPE J
 - STUDIO - TYPE J.1

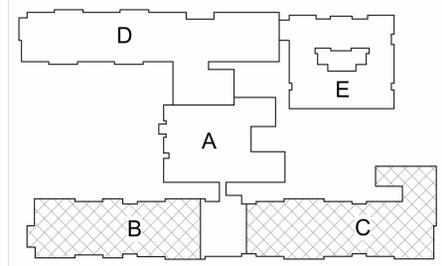

A10 LOWER LEVEL - OVERALL
 1" = 20'-0"



ARCHITECTURAL CORPORATION
 MISSOURI CERTIFICATE
 OF AUTHORITY NO. 000073

LEES SUMMIT SENIOR COMMUNITY
 5101 NE LAKEWOOD WAY
 LEES SUMMIT, JACKSON COUNTY, MISSOURI 64064

STARK WILSON DUNCAN ARCHITECTS INC
 315 NICHOLS ROAD STE 228 - KANSAS CITY, MO 64112 - T 816.531.1698
 WWW.SWDARCHITECTS.COM

SEAL
 ARCHITECT - TIMOTHY O.K. WILSON
 LICENSE NO. A-6972



OVERALL LOWER FLOOR PLAN

ISSUE DATE: 1.26.2026


REVISIONS:

NO.	DESCRIPTION	DATE

PROJECT NO.: 2510
A1.1
 COPYRIGHT © 2025 SWD ARCHITECTS INC



- Room Legend**
- 1 BDRM - TYPE E
 - 1 BDRM - TYPE E.1
 - 1 BDRM - TYPE F
 - 1 BDRM - TYPE K
 - 2 BDRM - TYPE G
 - 2 BDRM - TYPE H
 - 2 BDRM - TYPE L
 - STUDIO - TYPE A
 - STUDIO - TYPE A.1
 - STUDIO - TYPE B
 - STUDIO - TYPE C
 - STUDIO - TYPE C.1
 - STUDIO - TYPE D
 - STUDIO - TYPE J

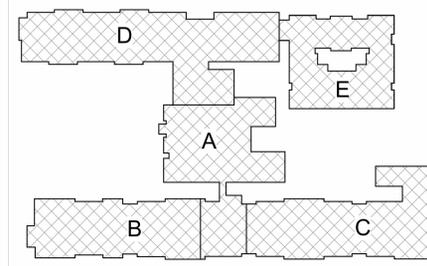

A10 FIRST FLOOR - OVERALL
1" = 20'-0"

SEAL
ARCHITECT - TIMOTHY O.K. WILSON
LICENSE NO. A-6972



OVERALL FIRST FLOOR PLAN

ISSUE DATE: 1.26.2026

REVISIONS:


NO.	DESCRIPTION	DATE

C:\Users\dtruskey\Documents\ORD LEES SUMMIT II - 01 SENIOR LIVING_dtruskey\6YP6R.rvt
1/23/2026 2:31:51 PM

C:\Users\dtruskey\Documents\ORD LEE'S SUMMIT II - 01 SENIOR LIVING_dtruskey\6YP6R.rvt
 1/23/2026 2:32:03 PM



- ### Room Legend
- 1 BDRM - TYPE E
 - 1 BDRM - TYPE K
 - 2 BDRM - TYPE G
 - 2 BDRM - TYPE L
 - 2 BDRM - TYPE M
 - STUDIO - TYPE C
 - STUDIO - TYPE J

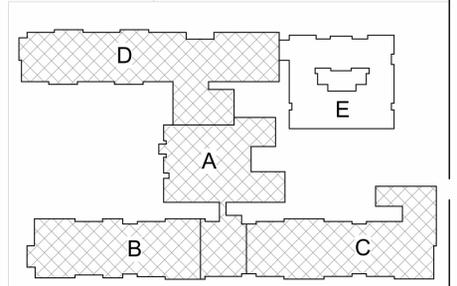

KEY PLAN

A10 SECOND FLOOR - OVERALL
 1" = 20'-0"



ARCHITECTURAL CORPORATION
 MISSOURI CERTIFICATE
 OF AUTHORITY NO. 000073

LEES SUMMIT SENIOR COMMUNITY
 5101 NE LAKEWOOD WAY
 LEES SUMMIT, JACKSON COUNTY, MISSOURI 64064

STARK WILSON DUNCAN ARCHITECTS INC
 315 NICHOLS ROAD STE 228 - KANSAS CITY, MO 64112 - T 816.531.1698
 WWW.SWDARCHITECTS.COM

SEAL
 ARCHITECT - TIMOTHY O.K. WILSON
 LICENSE NO. A-63972



OVERALL SECOND FLOOR PLAN


ISSUE DATE: 1.26.2026

REVISIONS:

NO.	DESCRIPTION	DATE

PROJECT NO.: 2510
A1.3
 COPYRIGHT © 2025 SWD ARCHITECTS INC

C:\Users\dtruskey\Documents\ORD - 04 VILLAS_dtruskey\YP6R.rvt
1/23/2026 2:22:17 PM

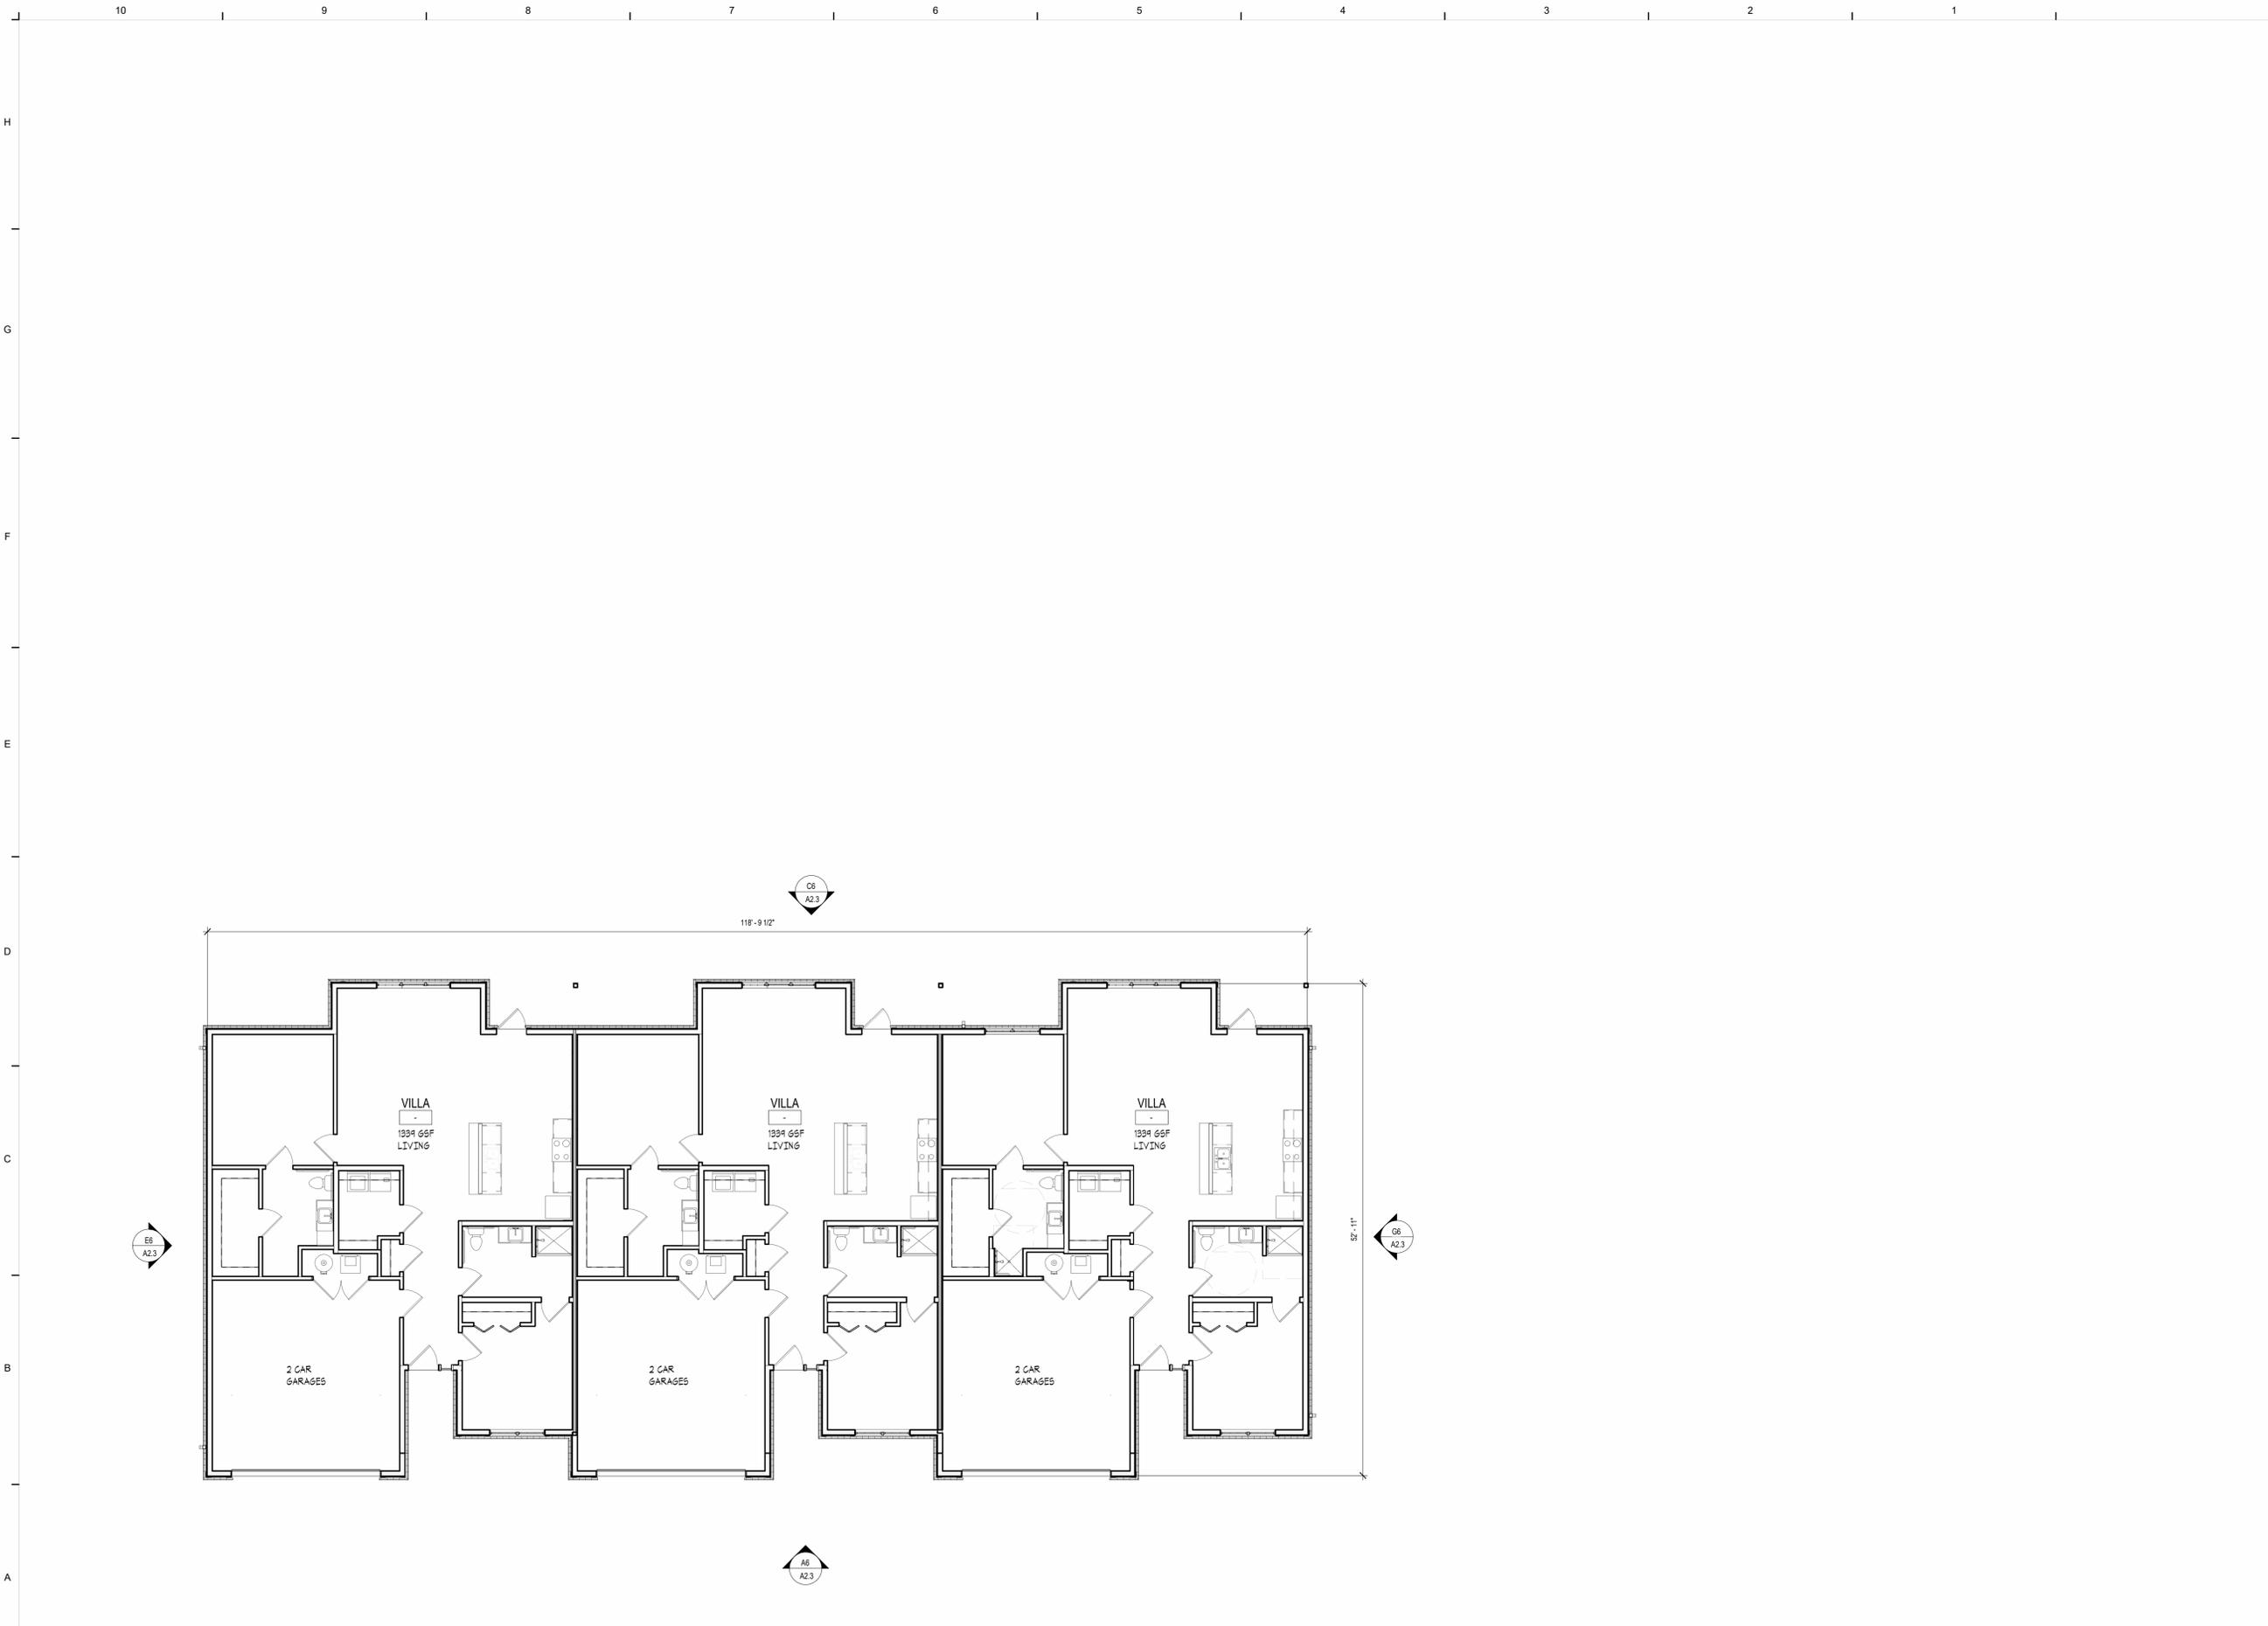

A10 FIRST FLOOR PLAN
1/8" = 1'-0"



ARCHITECTURAL CORPORATION
MISSOURI CERTIFICATE
OF AUTHORITY NO. 000073

LEES SUMMIT SENIOR COMMUNITY
5101 NE LAKEWOOD WAY
LEES SUMMIT, JACKSON COUNTY, MISSOURI 64064

STARK WILSON DUNCAN ARCHITECTS INC
315 NICHOLS ROAD STE 228 - KANSAS CITY, MO 64112 - T 816.531.1698
WWW.SWDARCHITECTS.COM

SEAL
ARCHITECT - TIMOTHY O.K. WILSON
LICENSE NO. A-6972



**OVERALL FLOOR
PLAN - VILLA**

ISSUE DATE:
1.26.2026

REVISIONS:

NO.	DESCRIPTION	DATE


PROJECT NO.:2510
A1.4



G10 PARTIAL SOUTH ELEVATION - IL
1/16" = 1'-0"




E10 PARTIAL NORTH ELEVATION - IL
1/16" = 1'-0"

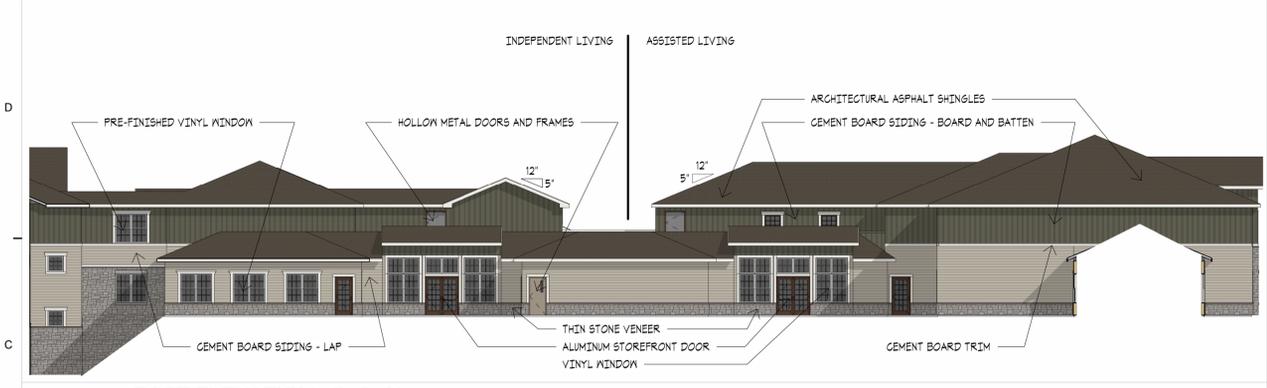


C10 EAST ELEVATION - IL & AL
1/16" = 1'-0"



C5 PARTIAL NORTH ELEVATION - IL
1/16" = 1'-0"

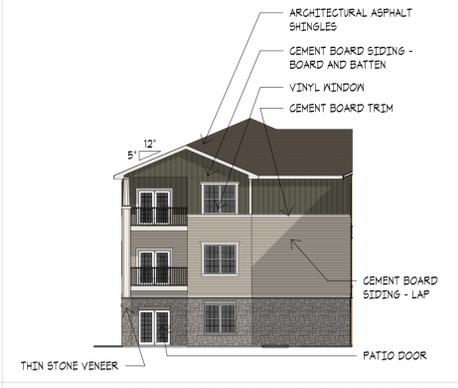


C3 PARTIAL WEST ELEVATION - IL
1/16" = 1'-0"

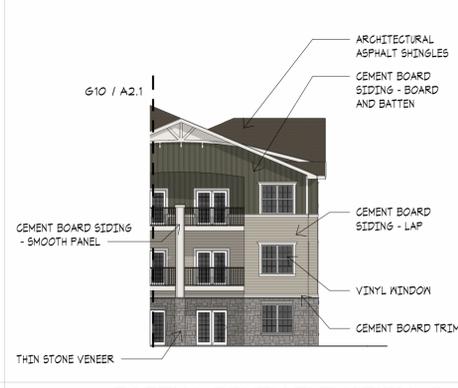

C1 PARTIAL SOUTH ELEVATION - IL
1/16" = 1'-0"



A10 WEST ELEVATION - IL & AL
1/16" = 1'-0"

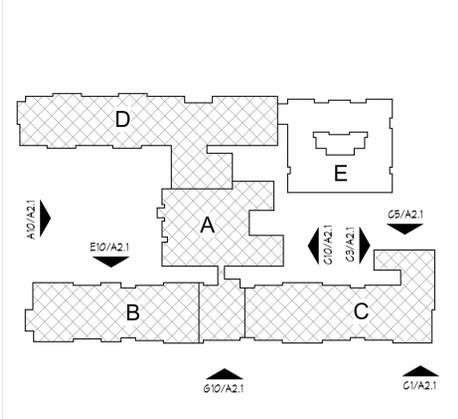

EXTERIOR FINISH LEGEND

	THIN STONE VENEER BORAL CULTURED STONE OR EQUAL COBBLEFIELD GRAY		CEMENT BOARD SIDING JAMES HARDIE OR EQUAL COLOR 2 BM NORTHERN CLIFFS 1936
	ALUM STOREFRONT MEDIUM BRONZE ANODIZED		CEMENT BOARD SIDING JAMES HARDIE OR EQUAL COLOR 3 SW 1004 SNOWBOUND
	WINDOWS WHITE		ASPHALT SHINGLES TAMKO HERITAGE OR EQUAL AGED WOOD
	CEMENT BOARD SIDING JAMES HARDIE OR EQUAL COLOR 1 BM MOHEGAN SAGE 2198-90		

SEAL
ARCHITECT - TIMOTHY O.K. WILSON
LICENSE NO. A-6972

1.26.2026

BUILDING ELEVATIONS

ISSUE DATE:
1.26.2026

REVISIONS:

NO.	DESCRIPTION	DATE

PROJECT NO.: 2510

A2.1

COPYRIGHT © 2025 SWD ARCHITECTS INC

C:\Users\dtruskey\Documents\ORD - LEE'S SUMMIT II - 01 SENIOR LIVING_dtruskey\8YP6R.rvt
1/26/2026 4:36:42 PM




G10 SOUTH ELEVATION - MCAL
1/16" = 1'-0"



E10 NORTH ELEVATION - MCAL
1/16" = 1'-0"




C10 SOUTH ELEVATION - IL
1/16" = 1'-0"

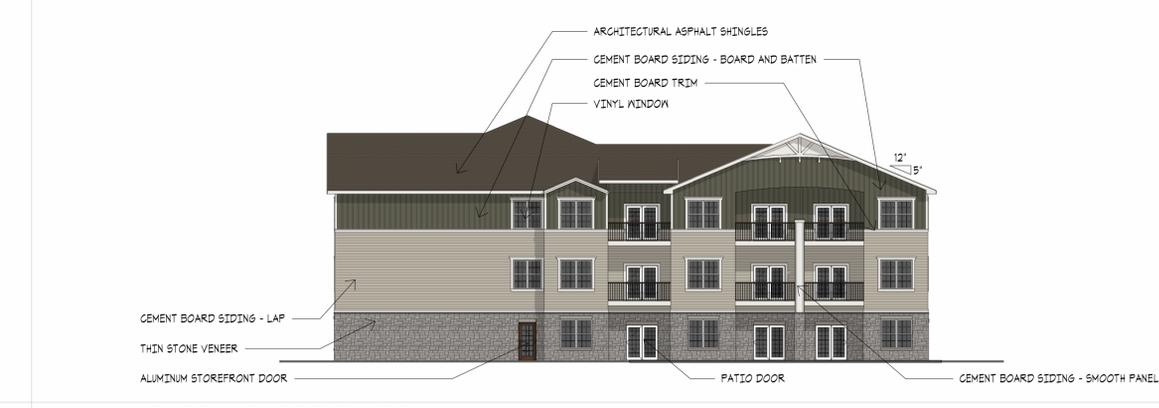


C4 PARTIAL EAST ELEVATION - IL
1/16" = 1'-0"



B10 EAST ELEVATION - MEMORY CARE
1/16" = 1'-0"

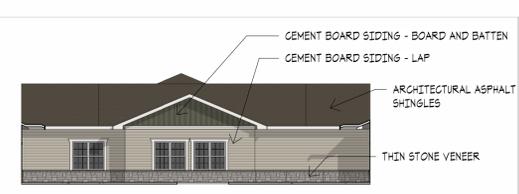

B7 SOUTH ELEVATION - MC COURTYARD
1/16" = 1'-0"

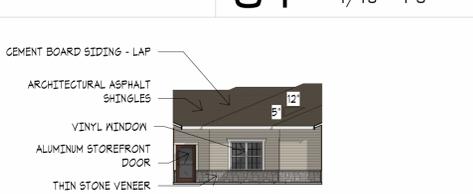

B5 EAST ELEVATION - MC COURTYARD
1/16" = 1'-0"




A10 WEST ELEVATION - MEMORY CARE
1/16" = 1'-0"



A7 NORTH ELEVATION - MC COURTYARD
1/16" = 1'-0"



A5 WEST ELEVATION - MC COURTYARD
1/16" = 1'-0"

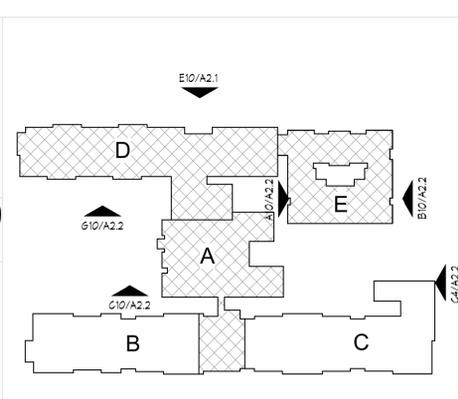

KEY PLAN

EXTERIOR FINISH LEGEND

	THIN STONE VENEER BORAL CULTURED STONE OR EQUAL COBBLEFIELD GRAY		CEMENT BOARD SIDING JAMES HARDIE OR EQUAL COLOR 2 BM NORTHERN CLIFFS 1936
	ALUM STOREFRONT MEDIUM BRONZE ANODIZED		CEMENT BOARD SIDING JAMES HARDIE OR EQUAL COLOR 3 SM 1004 SNOWBOUND
	WINDOWS WHITE		ASPHALT SHINGLES TAMKO HERITAGE OR EQUAL AGED WOOD
	CEMENT BOARD SIDING JAMES HARDIE OR EQUAL COLOR 1 BM MOHEGAN SAGE 2198-80		

SEAL
ARCHITECT - TIMOTHY O.K. WILSON
LICENSE NO. A-6972



BUILDING ELEVATIONS


ISSUE DATE:
1.26.2026
REVISIONS:
NO. DESCRIPTION DATE

PROJECT NO.: 2510
A2.2


C:\Users\dtruskey\Documents\ORD_LEE'S SUMMIT II - 01 SENIOR LIVING_dtruskey\8YP6R.rvt
1/23/2026 2:40:54 PM

LEES SUMMIT SENIOR COMMUNITY
5101 NE LAKEWOOD WAY
LEES SUMMIT, JACKSON COUNTY, MISSOURI 64064

STARK WILSON DUNCAN ARCHITECTS INC
315 NICHOLS ROAD STE 228 - KANSAS CITY, MO 64112 - T 816.531.1698
WWW.SWDARCHITECTS.COM

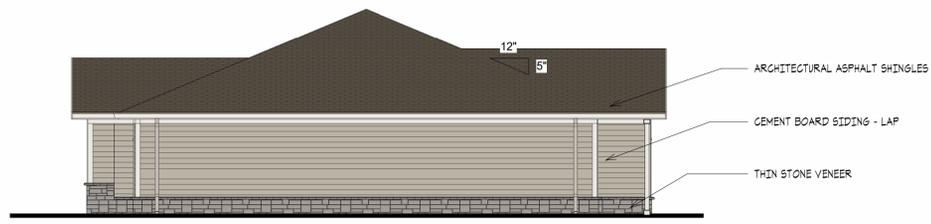

G6 EAST ELEVATION
1/8" = 1'-0"

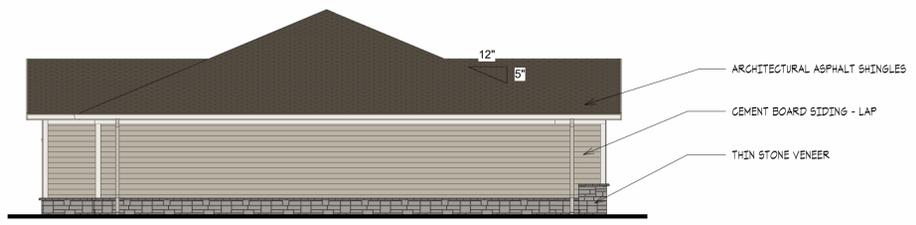

E6 WEST ELEVATION
1/8" = 1'-0"



C6 SOUTH ELEVATION
1/8" = 1'-0"



A6 NORTH ELEVATION
1/8" = 1'-0"

EXTERIOR FINISH LEGEND

	THIN STONE VENEER BORAL CULTURED STONE OR EQUAL COBBLEFIELD GRAY		CEMENT BOARD SIDING JAMES HARDIE OR EQUAL COLOR 2 BM NORTHERN CLIFFS 1936
	ALUM STOREFRONT MEDIUM BRONZE ANNOXIDIZED		CEMENT BOARD SIDING JAMES HARDIE OR EQUAL COLOR 3 SW 1004 SNOWBOUND
	WINDOWS WHITE		ASPHALT SHINGLE TAMKO HERITAGE OR EQUAL AGED WOOD
	CEMENT BOARD SIDING JAMES HARDIE OR EQUAL COLOR 1 BM MOHEGAN SAGE 2198-80		

SEAL
ARCHITECT - TIMOTHY O.K. WILSON
LICENSE NO. A-6972





BUILDING ELEVATIONS - VILLA

ISSUE DATE:
1.26.2026

REVISIONS:

NO.	DESCRIPTION	DATE

PROJECT NO.: 2510
A2.3
COPYRIGHT © 2025 SWD ARCHITECTS INC

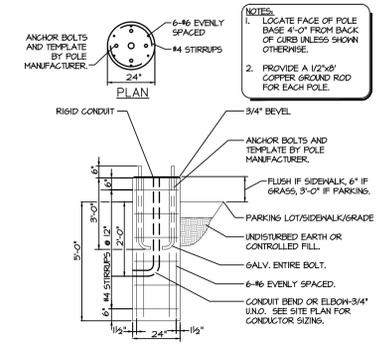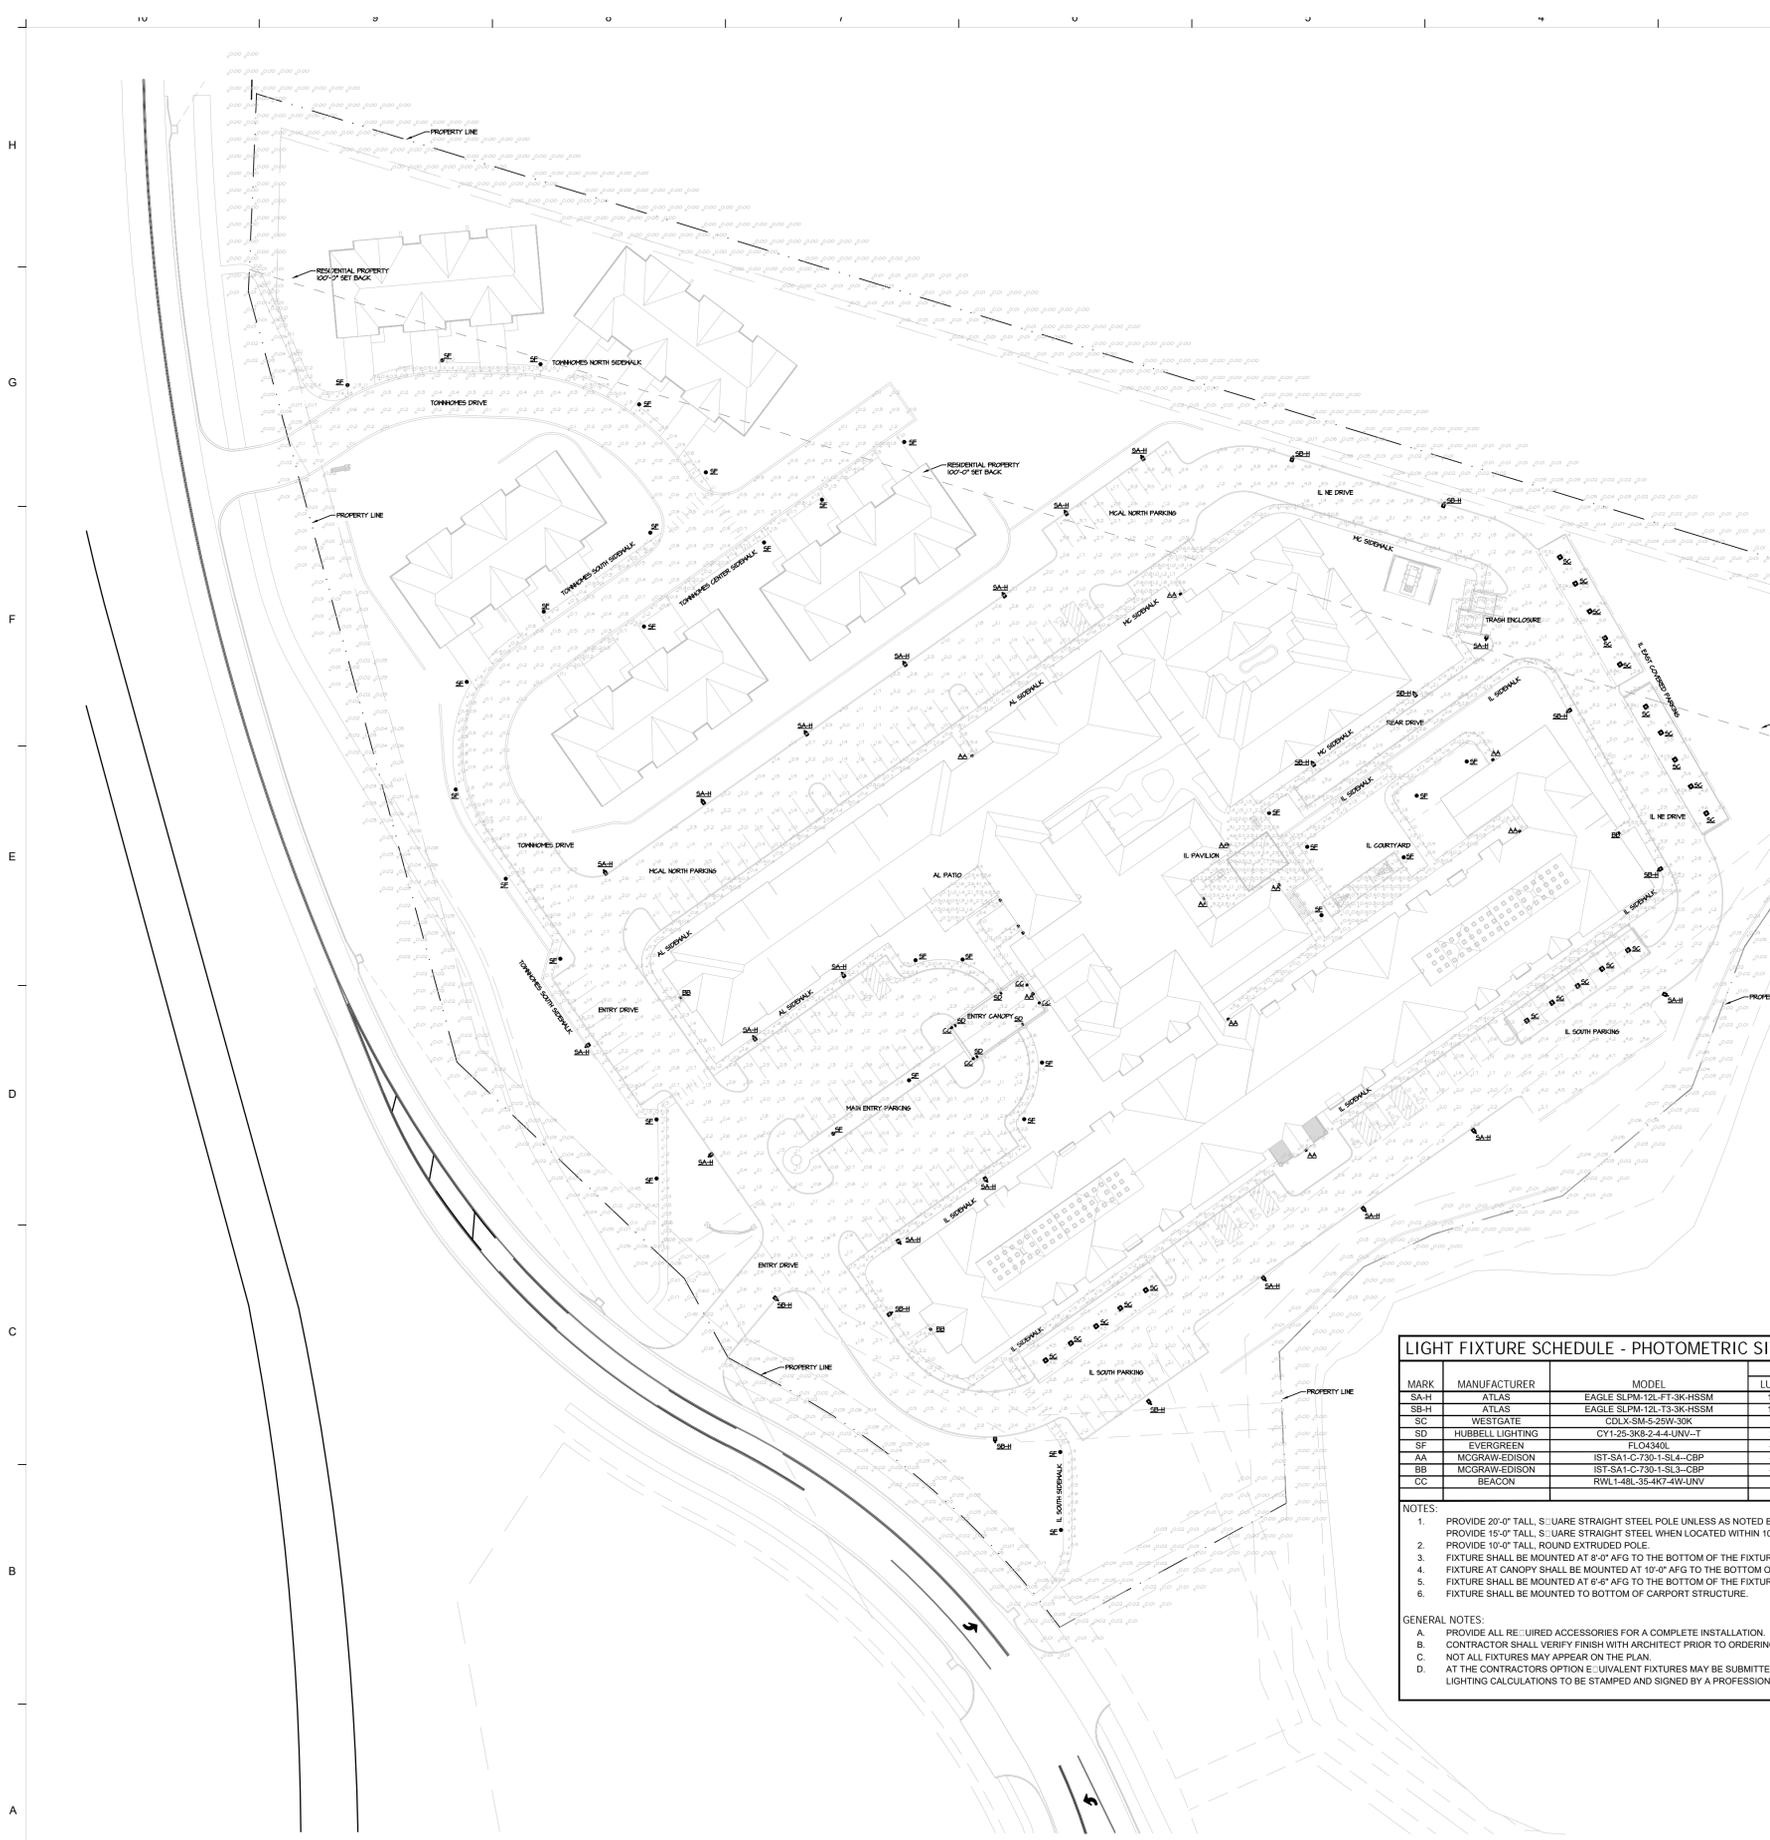

02 POLE BASE DETAIL
SCALE: NOT TO SCALE

PHOTOMETRIC STATISTICS						
DESCRIPTION	AVG (FC)	MAX (FC)	MIN (FC)	MAX/MIN (FC)	AVG/MIN (FC)	LLF
ENTRY DRIVE	1.7	3.4	0.5	6.8:1	3.4:1	0.81
IL NORTHEAST DRIVE	2.2	6.0	0.2	30:1:1	11.0:1	0.81
REAR DRIVE	3.0	7.0	1.5	4:1:1	2.0:1	0.81
TOWNHOMES DRIVE	0.4	1.3	0.0	N/A	N/A	0.81
IL SOUTH PARKING	2.0	5.1	0.2	25.5:1	10.0:1	0.81
IL EAST COVERED PARKING	4.3	5.5	1.9	2.9:1	2.3:1	0.81
MAIN ENTRY PARKING	1.5	3.0	0.6	5.0:1	2.5:1	0.81
MCAL NORTH PARKING	1.7	4.7	0.4	11.8:1	4.3:1	0.81
AL SIDEWALK	1.5	6.7	0.2	33.5:1	7.5:1	0.81
IL SIDEWALK	1.5	6.9	0.2	33.5:1	7.5:1	0.81
IL SOUTH SIDEWALK	0.9	2.0	0.1	20.0:1	9.0:1	0.81
MC SIDEWALK	1.1	4.8	0.0	N/A	N/A	0.81
TOWNHOMES CENTRAL SIDEWALK	0.7	1.5	0.1	15.0:1	7.0:1	0.81
TOWNHOMES NORTH SIDEWALK	0.7	1.5	0.0	N/A	N/A	0.81
TOWNHOMES SOUTH SIDEWALK	0.6	2.9	0.0	N/A	N/A	0.81
AL PATIO	2.3	5.8	0.5	11.6:1	4.6:1	0.81
IL COURTYARD	1.2	5.0	0.0	N/A	N/A	0.81
IL PAVILION	2.1	5.1	0.4	12.8:1	5.3:1	0.81
MAIN ENTRY CANOPY	2.4	5.5	0.8	6.9:1	3.0:1	0.81
TRASH ENCLOSURE	0.3	2.1	0.0	N/A	N/A	0.81

LIGHT FIXTURE SCHEDULE - PHOTOMETRIC SITE LIGHTING												
MARK	MANUFACTURER	MODEL	LAMP DATA			LIGHT	DISTRIB	VOLTS	MOUNTING	TOTAL WATTS	DESCRIPTION	NOTES
			LUMENS	TYPE	COLOR(K)							
SA-H	ATLAS	EAGLE SLP-M-12L-FT-3K-HSSM	11984	LED	3000K	T4-HSS	120-277	POLE TOP	75	LED LOW PROFILE PARKING LOT FIXTURE W/SS	1	
SB-H	ATLAS	EAGLE SLP-M-12L-T3-3K-HSSM	12220	LED	3000K	T3-HSS	120-277	POLE TOP	75	LED LOW PROFILE PARKING LOT FIXTURE W/SS	1	
SC	WESTGATE	CDLX-SM-5-25W-30K	3000	LED	3000K	T5	120-277	SURFACE	45	LED LOW PROFILE PARKING CANOPY FIXTURE	6	
SD	HUBBELL LIGHTING	CY1-25-3K8-2-4-UNV-T	2500	LED	3000K	T4-HSS	120-277	WALL	25	DIRECT/INDIRECT LED EXTERIOR WALL MOUNT	5	
SF	EVERGREEN	FLO4040L	4000	LED DRIVER	3000K	T5	120/277	POLE TOP	40	DECORATIVE POST TOP LED FIXTURE	2	
AA	MCGRAW-EDISON	IST-SA1-C-730-1-SL4-CBP	4500	LED	3000K	T4-HSS	120-277	WALL	35	TYPE SL4 LED EXTERIOR WALL MOUNT W/CWB	3.4	
BB	MCGRAW-EDISON	IST-SA1-C-730-1-SL3-CBP	4500	LED	3000K	T3-HSS	120-277	WALL	35	TYPE SL3 LED EXTERIOR WALL MOUNT W/CWB	3	
CC	BEACON	RWL1-48L-35-4K7-4W-UNV	800	LED	3000K	-	120	WALL	9	20" ONE LIGHT BLACK DECORATIVE EXT. SCANCE	5	

NOTES:
 1. PROVIDE 20'-0" TALL SQUARE STRAIGHT STEEL POLE UNLESS AS NOTED BELOW.
 PROVIDE 15'-0" TALL SQUARE STRAIGHT STEEL WHEN LOCATED WITHIN 100'-0" RESIDENTIAL SET BACK.
 2. PROVIDE 10'-0" TALL ROUND EXTRUDED POLE.
 3. FIXTURE SHALL BE MOUNTED AT 6'-0" AFG TO THE BOTTOM OF THE FIXTURE.
 4. FIXTURE AT CANOPY SHALL BE MOUNTED AT 10'-0" AFG TO THE BOTTOM OF THE FIXTURE.
 5. FIXTURE SHALL BE MOUNTED AT 6'-6" AFG TO THE BOTTOM OF THE FIXTURE.
 6. FIXTURE SHALL BE MOUNTED TO BOTTOM OF CARPORT STRUCTURE.

GENERAL NOTES:
 A. PROVIDE ALL REQUIRED ACCESSORIES FOR A COMPLETE INSTALLATION.
 B. CONTRACTOR SHALL VERIFY FINISH WITH ARCHITECT PRIOR TO ORDERING ALL FIXTURES.
 C. NOT ALL FIXTURES MAY APPEAR ON THE PLAN.
 D. AT THE CONTRACTORS OPTION E-UNVALENT FIXTURES MAY BE SUBMITTED. IF ALTERNATE FIXTURES ARE SUBMITTED AND ACCEPTED THE CONTRACTOR SHALL BE RESPONSIBLE FOR PROVIDING UPDATED LIGHTING CALCULATIONS TO BE STAMPED AND SIGNED BY A PROFESSIONAL ENGINEER FOR RESUBMISSION TO THE LOCAL JURISDICTIONS TO SHOW COMPLIANCE OF EXTERIOR LIGHTING REQUIREMENTS.

A12 PHOTOMETRIC SITE PLAN
1" = 50'-0"



ARCHITECTURAL CORPORATION
MISSOURI CERTIFICATE
OF AUTHORITY NO. 000073

LEE'S SUMMIT SENIOR COMMUNITY
5101 NE LAKEWOOD WAY
LEE'S SUMMIT, JACKSON COUNTY, MISSOURI 64064

STARK WILSON DUNCAN ARCHITECTS INC.
315 NICHOLS ROAD STE 228 - KANSAS CITY, MO 64112 - T 816.531.1698
WWW.SWDARCHITECTS.COM

SEAL
ENGINEER - CASEY J. STEINER
LICENSE NO. PE-2009035182



PHOTOMETRIC SITE PLAN

ISSUE DATE:
1.26.2026
REVISIONS:
NO. DESCRIPTION DATE



15902 Midland Drive
Shawnee, Kansas 66217
913.362.9090
Hoss & Brown Engineers 2026
MO Certificate of Authority 01022

PROJECT NO.: 2510
PH1.1
COPYRIGHT 2026 SWD ARCHITECTS INC